

All construction shall be in accordance with the 2018 I.R.C. and applicable local jurisdiction amendments.
 Written dimensions on these drawings have precedence over scale dimensions. Contractors shall verify and be responsible for all dimensions and conditions of the job. SFD shall be notified in writing of any variations or discrepancies from the dimensions, conditions and specifications shown by these drawings.

NOTE:
 ALL STRUCTURAL INFORMATION PROVIDED IN STRUCTURAL DRAWINGS BY ENGINEER OR ARCHITECT TAKE PRECEDENCE OVER ANY STRUCTURAL INFORMATION PROVIDED IN THIS PLAN.
 PLAN REPRODUCTION AND LICENSING NOTICE
 The printing or reproduction of any kind for marketing, construction or any use of this plan is prohibited without the written permission of South Florida Design, Inc. The license number listed below grants the customer the right to construct one home from these plans at the specified legal description or address as stated in the license agreement. Any use of this plan or design without a valid license number will result in legal action as set forth by US Copyright law.
LICENSE # SFD-00908-1G1-4346



G1-4346-S
BRETT AND AMANDA BRANCH
SINGLE FAMILY HOME
3000 W. HIGHWAY 130
NEWCASTLE, OKLAHOMA 73065


Revisions		
No.	Date	Description
1		4
2		5
3		6

Drawn By: D.A.
 Plan No: G1-4346-S
 Date: 07-28-2025
 Reviewed: 03-06-23 KP

CONFIDENTIAL COPYRIGHT SOUTH FLORIDA DESIGN, INC. PURSUANT TO SECTION 102 OF THE COPYRIGHT ACT, 17 U.S.C. ALL CONCEPTS, IDEAS, DESIGNS, ARRANGEMENTS, DRAWINGS, AND PLANS INDICATED OR REPRESENTED BY THIS DOCUMENT ARE COPYRIGHTED BY SOUTH FLORIDA DESIGN, INC. AS SUCH ALL CONCEPTS, IDEAS, DESIGNS, ARRANGEMENTS, DRAWINGS, AND PLANS INDICATED OR REPRESENTED BY THIS DOCUMENT ARE OWNED BY AND THE PROPERTY OF SOUTH FLORIDA DESIGN, INC. AND WERE CREATED, EVOLVED AND DEVELOPED FOR ITS OWN USE. NONE OF THE IDEAS, DESIGNS, ARRANGEMENTS, DRAWINGS, AND PLANS SHALL BE USED BY OR DISCLOSED TO ANY PERSON, ARCHITECTURAL OR ENGINEERING FIRM, CONSTRUCTION FIRM, SUBCONTRACTOR, FIRM, SUPPLIER, OR CORPORATION FOR ANY PURPOSE WHATSOEVER WITHOUT THE WRITTEN PERMISSION OF SOUTH FLORIDA DESIGN, INC. PURSUANT TO SECTION 102 OF THE COPYRIGHT ACT, 17 U.S.C. PROTECTION FOR AN ARCHITECTURAL WORK CREATED AS A HOME MADE FOR SALE OR AFTER DECEMBER 1, 1990, LASTS FOR 95 YEARS FROM THE DATE OF CREATION OF THE UNPUBLISHED PLANS, AND FOR 70 YEARS FROM THE DATE OF CREATION OF THE UNPUBLISHED PLANS, WHICHEVER TERM IS LESS. WARNING: REPRODUCTION VIOLATES FEDERAL OR STATE LAWS. UNAUTHORIZED DISCLOSURE MAY CONSTITUTE TRADE SECRET MISAPPROPRIATION IN VIOLATION OF 18 U.S.C. 1831, 1832, AND OTHER LAWS. THE CONCEPTS, IDEAS, DESIGNS, ARRANGEMENTS, DRAWINGS, AND PLANS DISCLOSED ARE COPYRIGHTED AND HEREIN MAY BE PATENTED OR BE THE SUBJECT OF PENDING PATENT APPLICATION. ANYONE VIOLATING THE INTENT OF THIS COPYRIGHT PROTECTION WILL BE PROSECUTED TO THE FULL EXTENT OF THE FEDERAL, STATE AND LOCAL LAWS. WRITTEN DIMENSIONS ON THESE DOCUMENTS SHALL HAVE PRECEDENCE OVER SCALE DIMENSIONS. CONTRACTORS SHALL VERIFY AND BE RESPONSIBLE FOR ALL DIMENSIONS AND CONDITIONS ON THE JOB AND THIS OFFICE MUST BE NOTIFIED OF ANY VARIATION FROM THE DIMENSIONS AND CONDITIONS SHOWN BY THESE DRAWINGS. SHOP DRAWINGS AND OR DETAILS MUST BE SUBMITTED TO THIS OFFICE FOR REVIEW BEFORE PROCEEDING WITH FABRICATION.

- DRAWING LIST**
- A-1 - COVER SHEET
 - A-2 - SLAB PLAN
 - A-3 - NOTED PLAN
 - A-4 - DIMENSION PLAN
 - A-5 - ELECTRICAL PLAN
 - A-6 - FRONT AND RIGHT SIDE ELEVATION
 - A-7 - REAR AND LEFT SIDE ELEVATION
 - A-8 - ROOF PLAN
 - A-9 - BUILDING AND WALL SECTIONS
 - A-10 - DOOR AND WINDOW SCHEDULES
 - A-11 - CEILING DETAILS

COVER SHEET

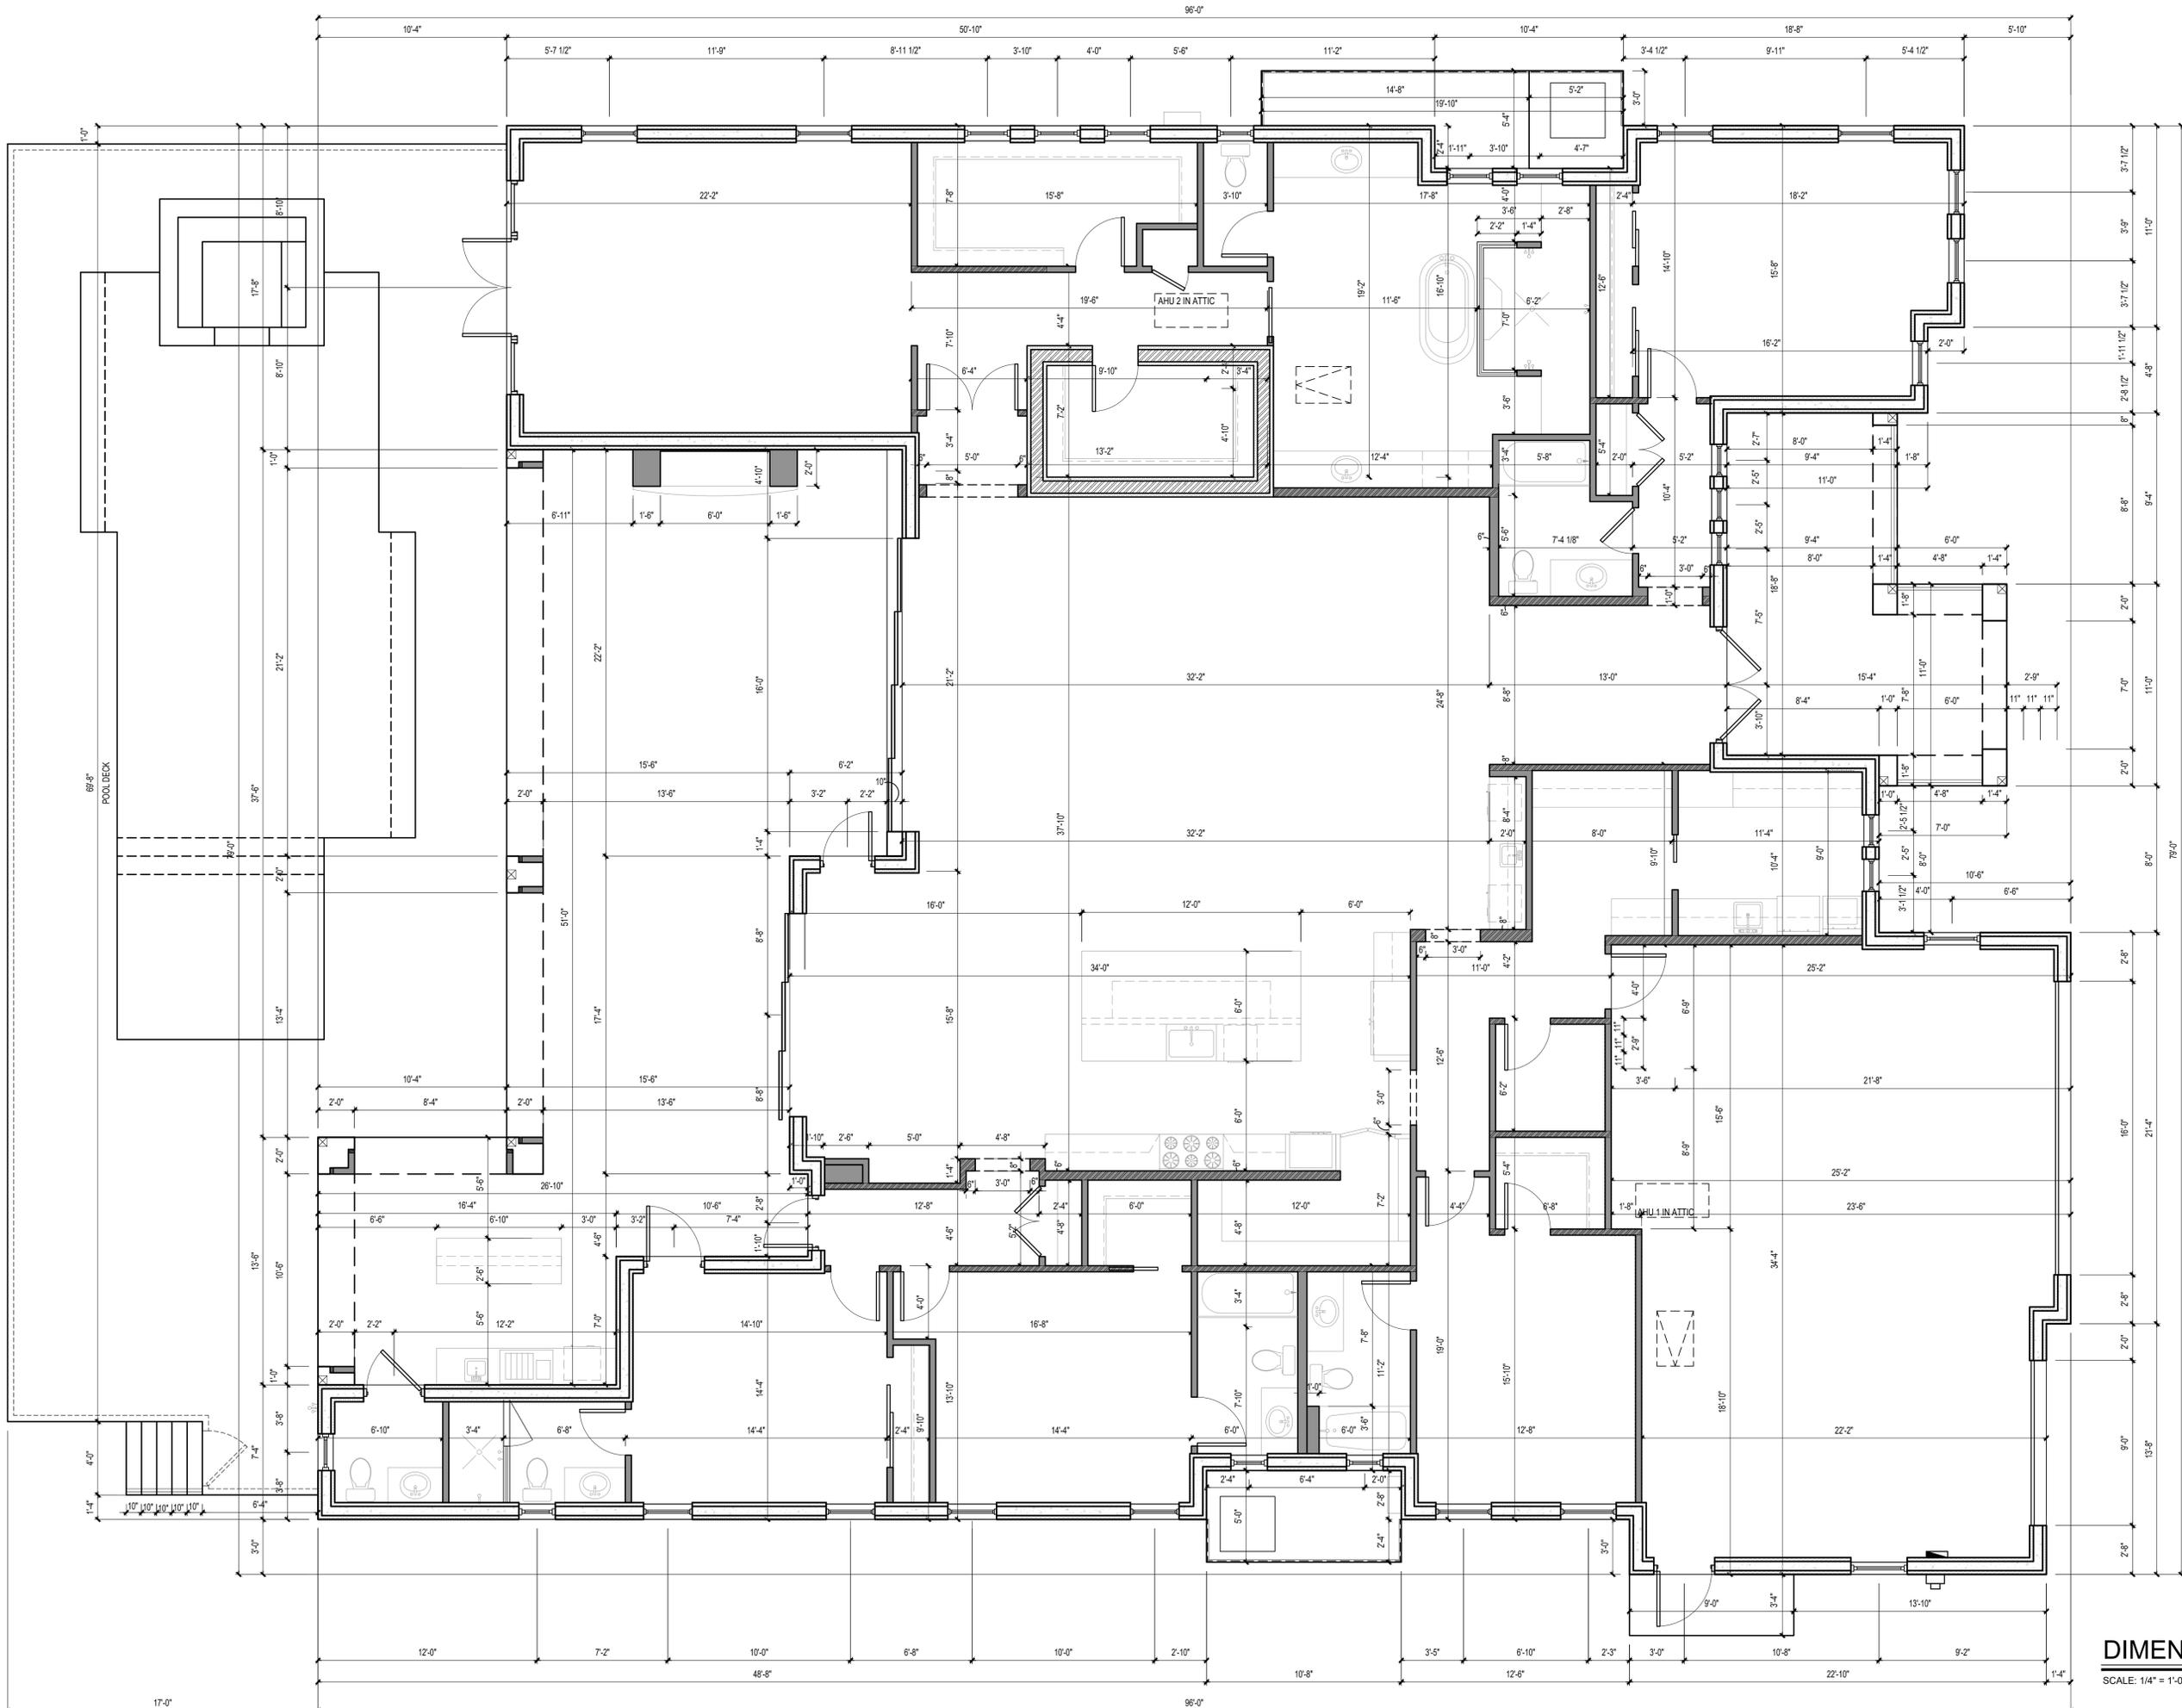

SFD
South Florida Design, Inc.
 8899 Timberwilde Dr.
 Suite 2
 Bonita Springs, FL 34135
 (239)-431-1818

All construction shall be in accordance with the 2018 I.R.C. and applicable local jurisdiction amendments.
 Written dimensions on these drawings have precedence over scale dimensions. Contractors shall verify and be responsible for all dimensions and conditions of the job. SFD shall be notified in writing of any variations or discrepancies from the dimensions, conditions and specifications shown by these drawings.

NOTE:
 ALL STRUCTURAL INFORMATION PROVIDED IN STRUCTURAL DRAWINGS BY ENGINEER OR ARCHITECT TAKE PRECEDENCE OVER ANY STRUCTURAL INFORMATION PROVIDED IN THIS PLAN.
 PLAN REPRODUCTION AND LICENSING NOTICE
 The printing or reproduction of any kind for marketing, construction or any use of this drawing without the written permission of South Florida Design, Inc. is prohibited. The license number listed below grants the customer the right to construct one home from these plans at the specified legal description or address as stated in the license agreement. Any use of this plan or design without a valid license number will result in legal action as set forth by US Copyright law.
 LICENSE # **SFD-00908-1G1-4346**

G1-4346-S
BRETT AND AMANDA BRANCH
SINGLE FAMILY HOME
3000 W. HIGHWAY 130
NEWCASTLE, OKLAHOMA 73065

Revisions		
No.	Date	Description
1		4
2		5
3		6

Drawn By: D.A.
 Plan No: G1-4346-S
 Date: 07-28-2025
 Reviewed: 03-06-23 KP

CONFIDENTIAL COPYRIGHT SOUTH FLORIDA DESIGN, INC. PURSUANT TO SECTION 102 OF THE COPYRIGHT ACT, 17 U.S.C. ALL CONCEPTS, IDEAS, DESIGNS, ARRANGEMENTS, DRAWINGS, AND PLANS INDICATED OR REPRESENTED BY THIS DOCUMENT ARE COPYRIGHTED BY SOUTH FLORIDA DESIGN, INC. AS SUCH ALL CONCEPTS, IDEAS, DESIGNS, ARRANGEMENTS, DRAWINGS, AND PLANS INDICATED OR REPRESENTED BY THIS DOCUMENT ARE OWNED BY AND ARE THE PROPERTY OF SOUTH FLORIDA DESIGN, INC. AND WERE CREATED, EVOLVED AND DEVELOPED FOR ITS OWN USE AND ARE NOT TO BE REPRODUCED OR TRANSMITTED IN ANY FORM OR BY ANY MEANS, ELECTRONIC OR MECHANICAL, INCLUDING PHOTOCOPYING, RECORDING, OR BY ANY INFORMATION STORAGE AND RETRIEVAL SYSTEM, WITHOUT THE WRITTEN PERMISSION OF SOUTH FLORIDA DESIGN, INC. PURSUANT TO SECTION 102 OF THE COPYRIGHT ACT, 17 U.S.C. PROTECTION FOR ARCHITECTURAL WORKS AS A HOME MADE FOR SALE OR AFTER DECEMBER 1, 1990, LASTS FOR 95 YEARS FROM THE DATE OF CREATION OF THE WORK OR FOR 120 YEARS FROM THE DATE OF CREATION OF THE UNPUBLISHED PLANS, WHICHEVER TERM ELIGIBLE. REPRODUCTION OR USE FOR ANY OTHER PURPOSE WITHOUT THE WRITTEN PERMISSION OF SOUTH FLORIDA DESIGN, INC. CONSTITUTE TRADE SECRET MISAPPROPRIATION IN VIOLATION OF 17 C.F.R. 201.103. ALL OTHER RIGHTS ARE RESERVED. UNAUTHORIZED DISSEMINATION OF CONCEPTS, IDEAS, DESIGNS, ARRANGEMENTS, DRAWINGS, AND PLANS DISCLOSED ARE COPYRIGHTED AND HEREBY BE PATENTED OR IN THE SUBJECT OF PENDING PATENT APPLICATION. ANYONE VIOLATING THE INTENT OF THIS COPYRIGHT PROTECTION WILL BE PROSECUTED TO THE FULL EXTENT OF THE FEDERAL, STATE AND LOCAL LAWS. WRITTEN DIMENSIONS ON THESE DOCUMENTS SHALL HAVE PRECEDENCE OVER SCALE DIMENSIONS. CONTRACTORS SHALL VERIFY AND BE RESPONSIBLE FOR ALL DIMENSIONS AND CONDITIONS ON THE JOB AND THIS OFFICE MUST BE NOTIFIED OF ANY VARIATION FROM THE DIMENSIONS AND CONDITIONS SHOWN BY THESE DRAWINGS. SHOP DRAWINGS AND DETAILS MUST BE SUBMITTED TO THIS OFFICE FOR REVIEW BEFORE PROCEEDING WITH FABRICATION.

DIMENSION PLAN
 SCALE: 1/4" = 1'-0"

SHEET
A-4
 PERMIT SET

All construction shall be in accordance with the 2018 I.R.C. and applicable local jurisdiction amendments. Written dimensions on these drawings have precedence over scale dimensions. Contractors shall verify and be responsible for all dimensions and conditions of the job. SFD shall be notified in writing of any variations or discrepancies from the dimensions, conditions and specifications shown by these drawings.


NOTE:
 ALL STRUCTURAL INFORMATION PROVIDED IN STRUCTURAL DRAWINGS BY ENGINEER OR ARCHITECT TAKE PRECEDENCE OVER ANY STRUCTURAL INFORMATION PROVIDED IN THIS PLAN. PLAN REPRODUCTION AND LICENSING NOTICE
 The printing or reproduction of any kind for marketing, construction or any use of this drawing without the written permission of South Florida Design, Inc. is prohibited. The license number listed below grants the customer the right to construct one home from these plans at the specified legal description or address as stated in the license agreement. Any use of this plan or design without a valid license number will result in legal action as set forth by US Copyright Law.
LICENSE # SFD-00908-1G1-4346

G1-4346-S
BRETT AND AMANDA BRANCH
SINGLE FAMILY HOME
3000 W. HIGHWAY 130
NEWCASTLE, OKLAHOMA 73065


Revisions		
No.	Date	Date
1		4
2		5
3		6

Drawn By: D.A.
 Plan No: G1-4346-S
 Date: 07-28-2025
 Reviewed: 03-06-23 KP



CONFIDENTIAL COPYRIGHT SOUTH FLORIDA DESIGN, INC. PURSUANT TO SECTION 102 OF THE COPYRIGHT ACT, 17 U.S.C. ALL CONCEPTS, IDEAS, DESIGNS, ARRANGEMENTS, DRAWINGS, AND PLANS INDICATED OR REPRESENTED BY THIS DOCUMENT ARE COPYRIGHTED BY SOUTH FLORIDA DESIGN, INC. AS SUCH ALL CONCEPTS, IDEAS, DESIGNS, ARRANGEMENTS, DRAWINGS, AND PLANS INDICATED OR REPRESENTED BY THIS DOCUMENT ARE OWNED BY AND THE PROPERTY OF SOUTH FLORIDA DESIGN, INC. AND WERE CREATED, EVOLVED AND DEVELOPED FOR ITS OWN USE AND ARE NOT TO BE REPRODUCED, COPIED, REPRODUCED, OR TRANSMITTED IN ANY FORM OR BY ANY MEANS, ELECTRONIC OR MECHANICAL, INCLUDING PHOTOCOPYING, RECORDING, OR BY ANY INFORMATION STORAGE AND RETRIEVAL SYSTEM, WITHOUT THE WRITTEN PERMISSION OF SOUTH FLORIDA DESIGN, INC. PURSUANT TO SECTION 102 OF THE COPYRIGHT ACT, 17 U.S.C. PROTECTION FOR ARCHITECTURAL WORK CREATED AS A HOME MADE FOR HIRE OR AFTER DECEMBER 1, 1990, LASTS FOR 95 YEARS FROM THE DATE OF CREATION OF THE WORK OR FOR 120 YEARS FROM THE DATE OF CREATION OF THE UNPUBLISHED PLANS, WHICHEVER TERM ELIGES. REPRODUCTION OR USE OF A CONCEPT, TRADE SECRET MISAPPROPRIATION IN VIOLATION OF 17 U.S.C. 18 U.S.C. 1832. UNAUTHORIZED DISCLOSURE MAY CONSTITUTE TRADE SECRET MISAPPROPRIATION IN VIOLATION OF 18 U.S.C. 1832. ALL RIGHTS RESERVED. THE CONCEPTS, IDEAS, DESIGNS, ARRANGEMENTS, DRAWINGS, AND PLANS DISCLOSED ARE COPYRIGHTED AND HEREIN MAY BE PATENTED OR BE THE SUBJECT OF PENDING PATENT APPLICATION. ANYONE VIOLATING THE INTENT OF THIS COPYRIGHT PROTECTION WILL BE PROSECUTED TO THE FULL EXTENT OF THE FEDERAL, STATE AND LOCAL LAWS. WRITTEN DIMENSIONS ON THESE DOCUMENTS SHALL HAVE PRECEDENCE OVER SCALE DIMENSIONS. CONTRACTORS SHALL VERIFY AND BE RESPONSIBLE FOR ALL DIMENSIONS AND CONDITIONS ON THE JOB AND THIS OFFICE MUST BE NOTIFIED OF ANY VARIATION FROM THE DIMENSIONS AND CONDITIONS SHOWN IN THESE DRAWINGS. SHOP DRAWINGS AND/OR DETAILS MUST BE SUBMITTED TO THIS OFFICE FOR REVIEW BEFORE PROCEEDING WITH FABRICATION.

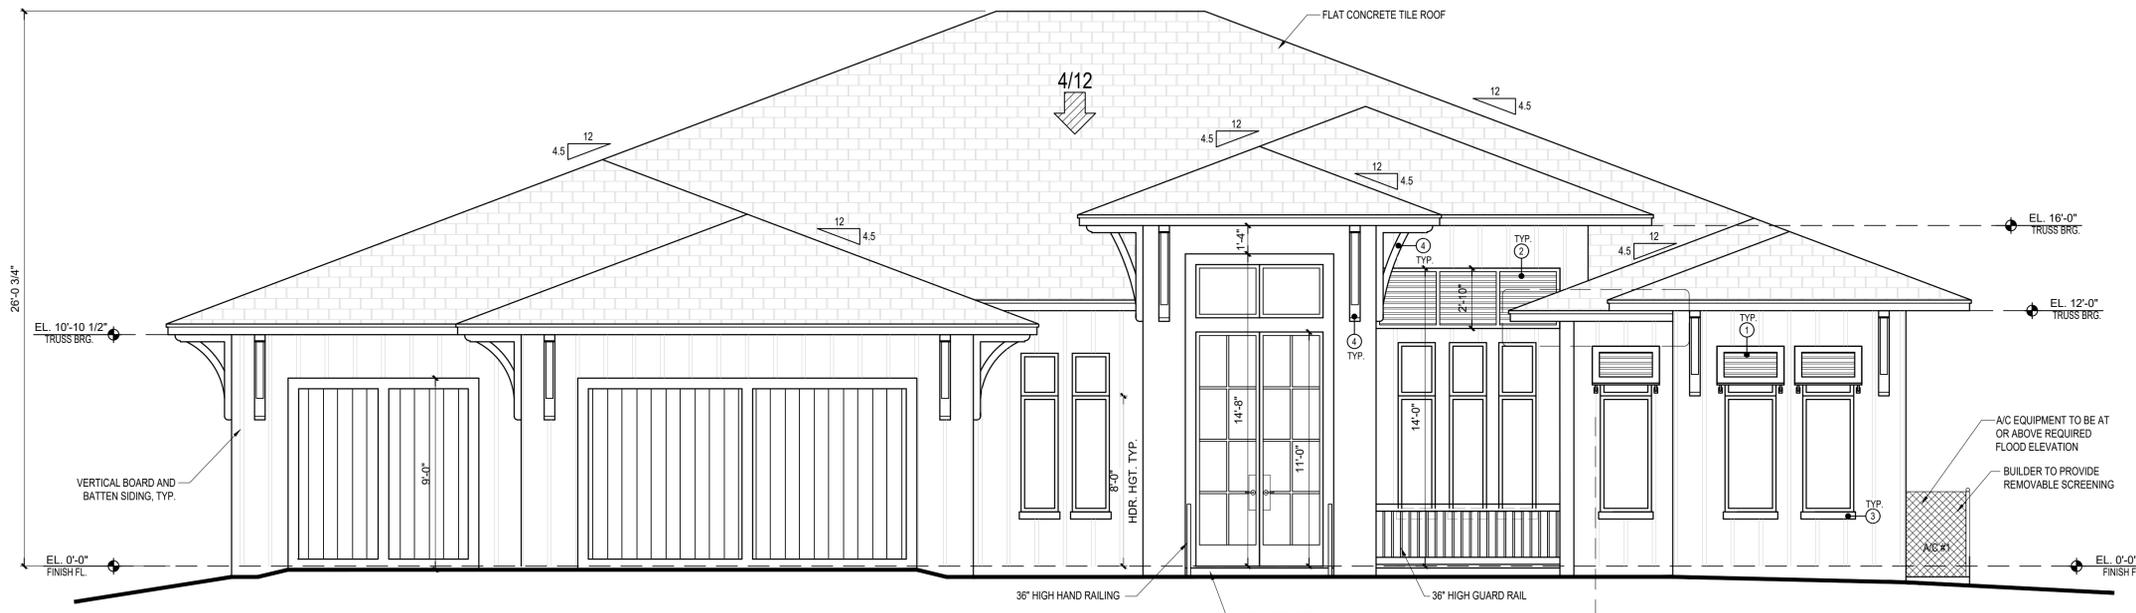

FRONT ELEVATION

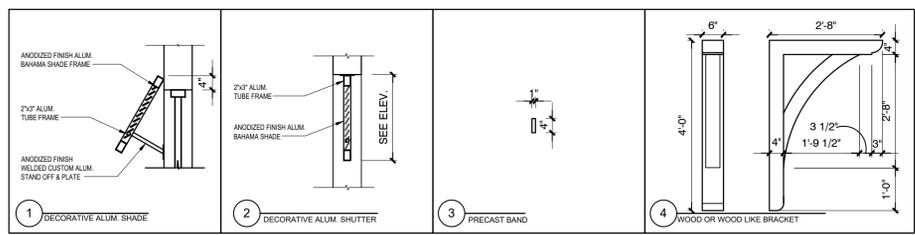

DETAILS

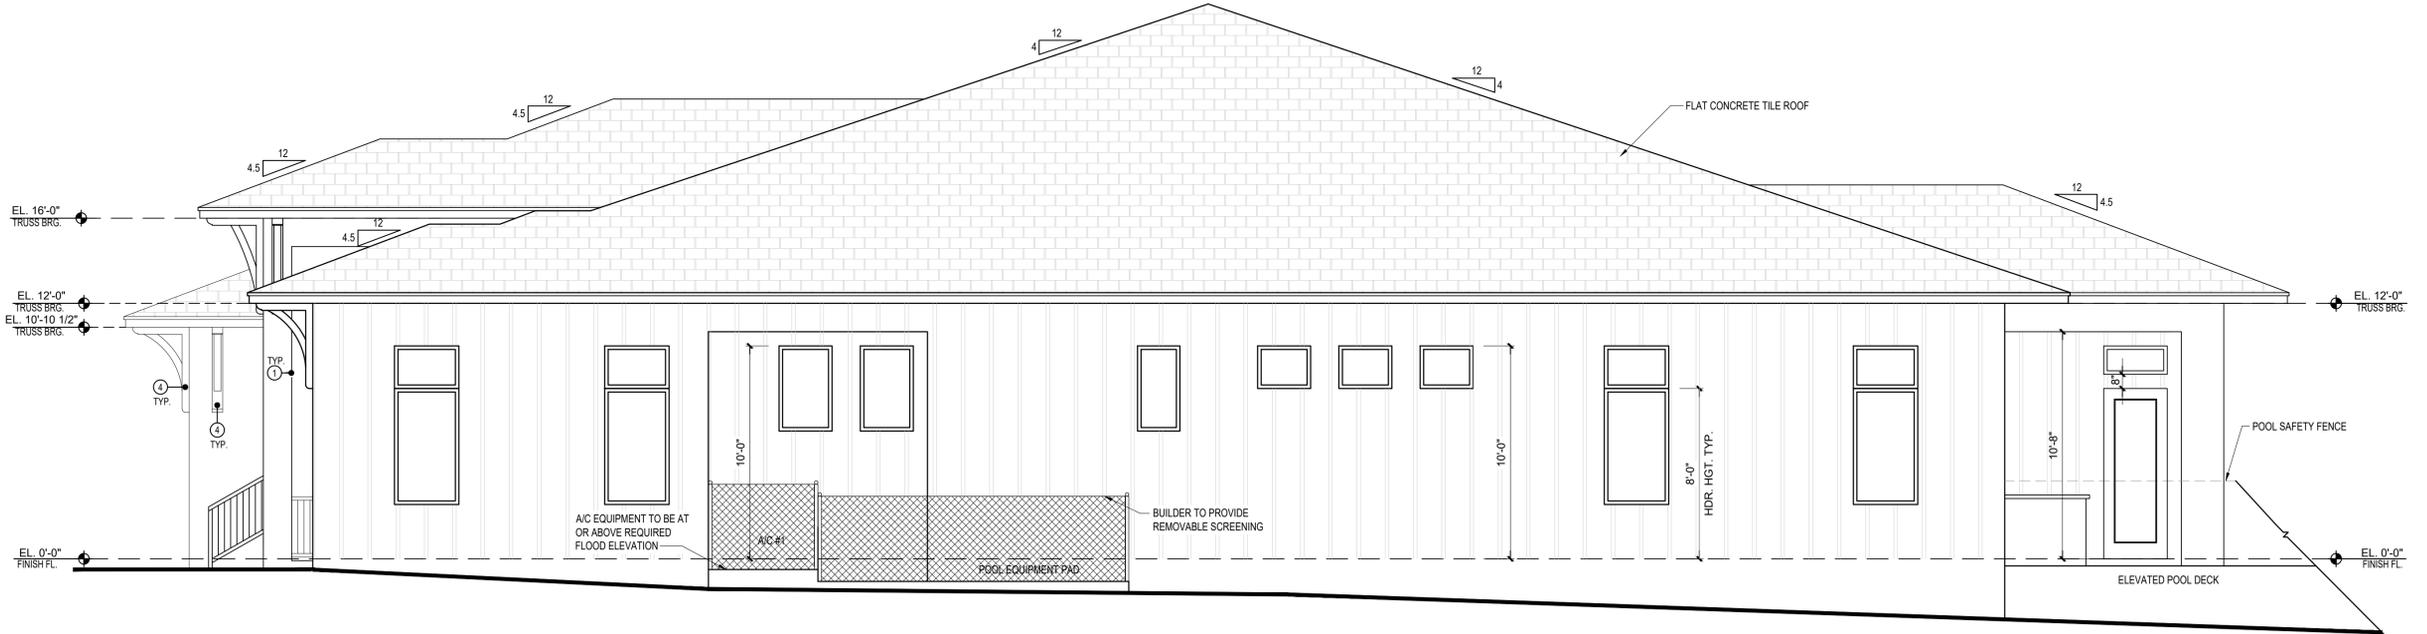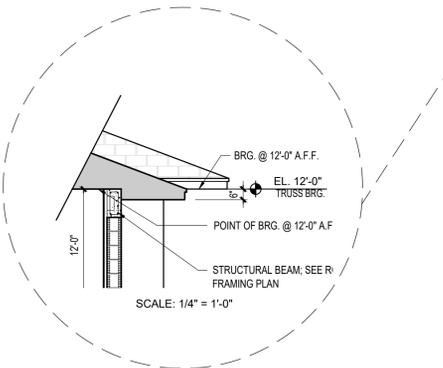


RIGHT-SIDE ELEVATION

SCALE: 1/4" = 1'-0"


All construction shall be in accordance with the 2018 I.R.C. and applicable local jurisdiction amendments.
 Written dimensions on these drawings have precedence over scale dimensions. Contractors shall verify and be responsible for all dimensions and conditions of the job. SFD shall be notified in writing of any variations or discrepancies from the dimensions, conditions and specifications shown by these drawings.

NOTE:
 ALL STRUCTURAL INFORMATION PROVIDED IN STRUCTURAL DRAWINGS BY ENGINEER OR ARCHITECT TAKE PRECEDENCE OVER ANY STRUCTURAL INFORMATION PROVIDED IN THIS PLAN.
 PLAN REPRODUCTION AND LICENSING NOTICE
 The printing or reproduction of any kind for marketing, construction or any use of this drawing without the written permission of South Florida Design, Inc. is prohibited. The license number listed below grants the customer the right to construct one home from these plans at the specified legal description or address as stated in the license agreement. Any use of this plan or design without a valid license number will result in legal action as set forth by US Copyright Law.
 LICENSE # **SFD-00908-1G1-4346**

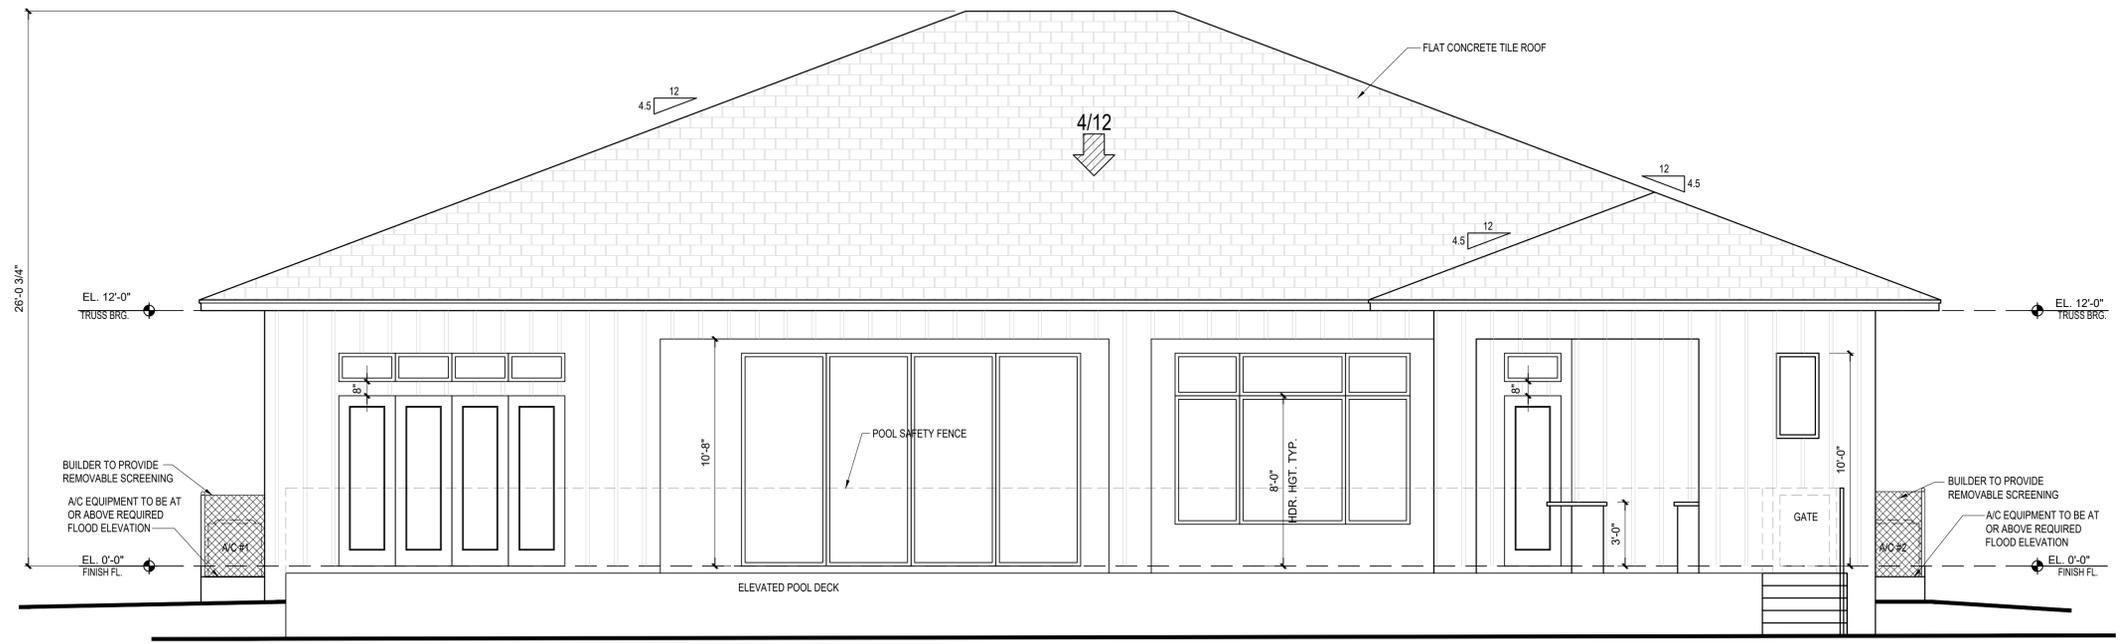


REAR ELEVATION

SCALE: 1/4" = 1'-0"

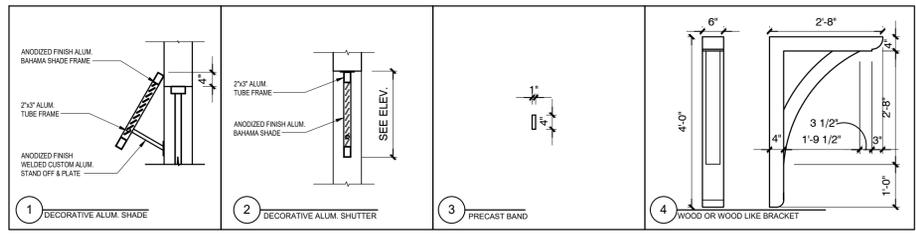

DETAILS

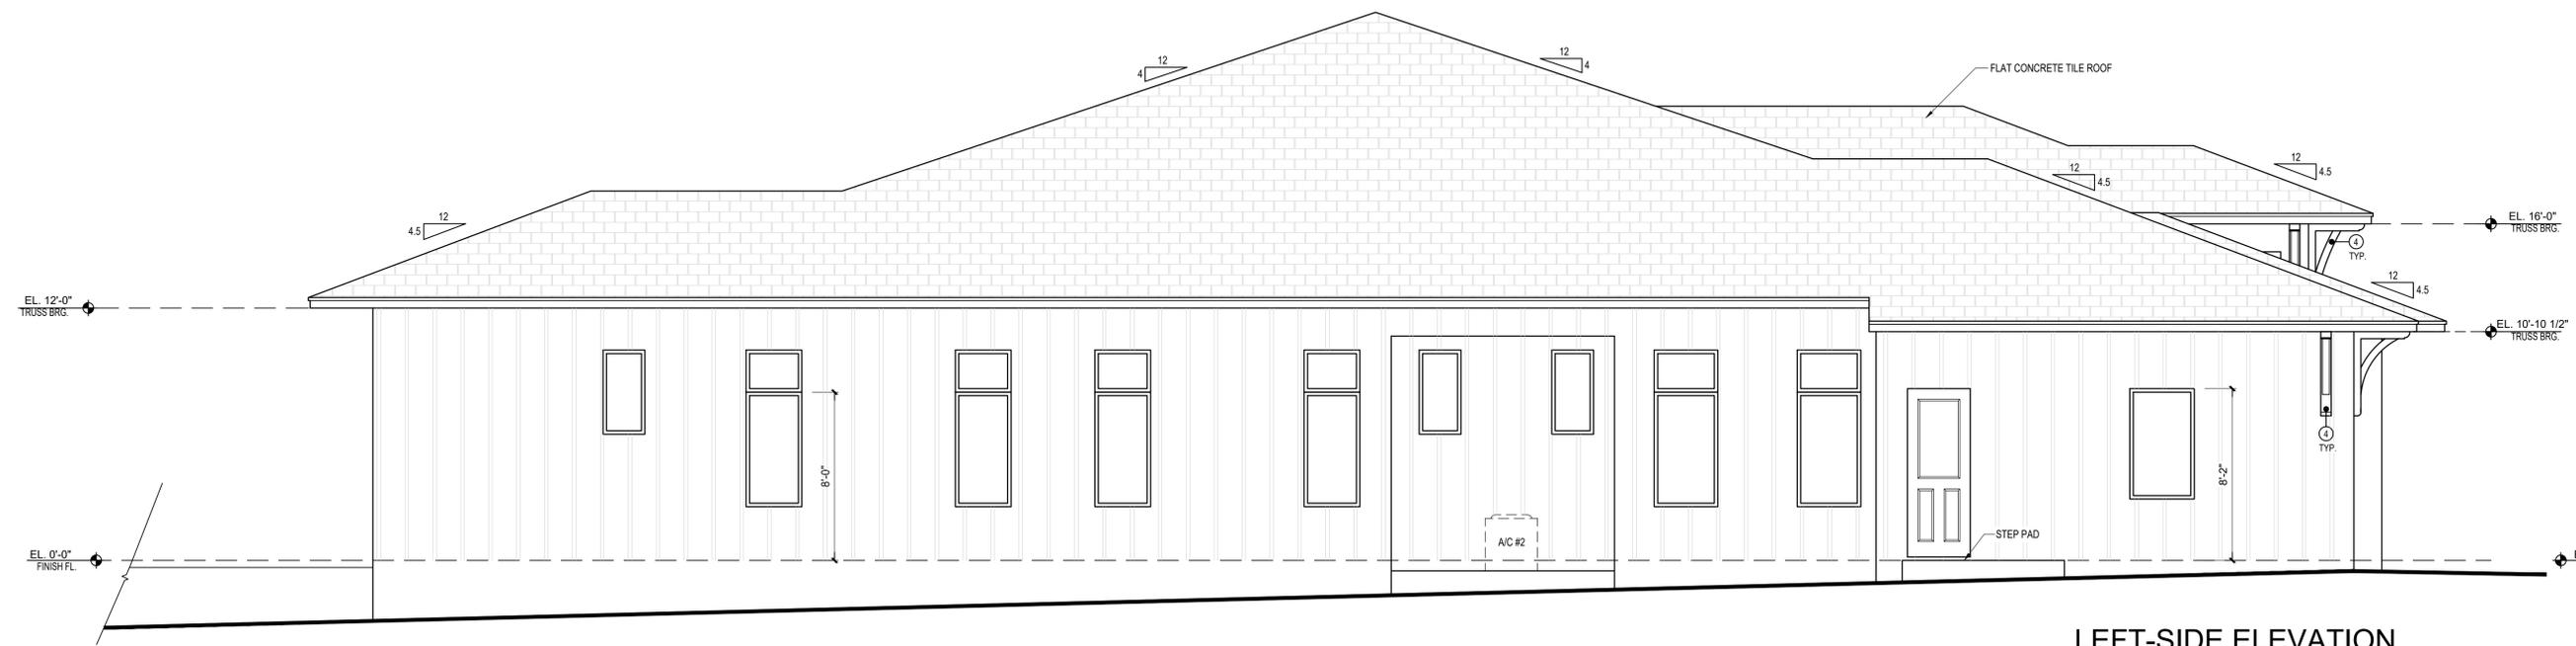

LEFT-SIDE ELEVATION

SCALE: 1/4" = 1'-0"

G1-4346-S
BRETT AND AMANDA BRANCH
SINGLE FAMILY HOME
3000 W. HIGHWAY 130
NEWCASTLE, OKLAHOMA 73065

Revisions		
No.	Date	Description
1		4
2		5
3		6

Drawn By: D.A.
 Plan No: G1-4346-S
 Date: 07-28-2025
 Reviewed: 03-06-23 KP

CONFIDENTIAL COPYRIGHT SOUTH FLORIDA DESIGN, INC. PURSUANT TO SECTION 102 OF THE COPYRIGHT ACT, 17 U.S.C. ALL CONCEPTS, IDEAS, DESIGNS, ARRANGEMENTS, DRAWINGS, AND PLANS INDICATED OR REPRESENTED BY THIS DOCUMENT ARE COPYRIGHTED BY SOUTH FLORIDA DESIGN, INC. AS SUCH ALL CONCEPTS, IDEAS, DESIGNS, ARRANGEMENTS, DRAWINGS, AND PLANS INDICATED OR REPRESENTED BY THIS DOCUMENT ARE OWNED BY AND THE PROPERTY OF SOUTH FLORIDA DESIGN, INC. AND WERE CREATED, EVOLVED AND DEVELOPED FOR ITS OWN USE AND NOT TO BE REPRODUCED, COPIED, REPRODUCED, OR TRANSMITTED IN ANY MANNER OR BY ANY MEANS, WITHOUT THE WRITTEN PERMISSION OF SOUTH FLORIDA DESIGN, INC. PURSUANT TO SECTION 102 OF THE COPYRIGHT ACT, 17 U.S.C. PROTECTION FOR ARCHITECTURAL, WORK CREATED AS A HOME MADE FOR HIRE OR AFTER DECEMBER 1, 1990, LASTS FOR 95 YEARS FROM THE DATE OF CREATION OF THE UNPUBLISHED PLANS, DRAWINGS, AND OTHER MATERIALS, OR 120 YEARS FROM THE DATE OF CREATION OF THE UNPUBLISHED PLANS, DRAWINGS, AND OTHER MATERIALS, WHICHEVER IS LONGER. ANY REPRODUCTION OR TRANSMISSION OF THESE DOCUMENTS WITHOUT THE WRITTEN PERMISSION OF SOUTH FLORIDA DESIGN, INC. CONSTITUTE TRADE SECRET MISAPPROPRIATION IN VIOLATION OF 18 U.S.C. 1832 AND OTHER LAWS. THE CONCEPTS, IDEAS, DESIGNS, ARRANGEMENTS, DRAWINGS, AND PLANS DISCLOSED ARE COPYRIGHTED AND HEREIN MAY BE PATENTED OR BE THE SUBJECT OF PENDING PATENT APPLICATION. ANYONE VIOLATING THE INTENT OF THIS COPYRIGHT PROTECTION WILL BE PROSECUTED TO THE FULL EXTENT OF THE FEDERAL, STATE AND LOCAL LAWS. WRITTEN DIMENSIONS ON THESE DOCUMENTS SHALL HAVE PRECEDENCE OVER SCALE DIMENSIONS. CONTRACTORS SHALL VERIFY AND BE RESPONSIBLE FOR ALL DIMENSIONS AND CONDITIONS ON THE JOB AND THIS OFFICE MUST BE NOTIFIED OF ANY VARIATION FROM THE DIMENSIONS AND CONDITIONS SHOWN ON THESE DRAWINGS. SHOP DRAWINGS AND DETAILS MUST BE SUBMITTED TO THIS OFFICE FOR REVIEW BEFORE PROCEEDING WITH FABRICATION.

All construction shall be in accordance with the 2018 I.R.C. and applicable local jurisdiction amendments.
 Written dimensions on these drawings have precedence over scale dimensions. Contractors shall verify and be responsible for all dimensions and conditions of the job. SFD shall be notified in writing of any variations or discrepancies from the dimensions, conditions and specifications shown by these drawings.



NOTE: ALL STRUCTURAL INFORMATION PROVIDED IN STRUCTURAL DRAWINGS BY ENGINEER OR ARCHITECT TAKE PRECEDENCE OVER ANY STRUCTURAL INFORMATION PROVIDED IN THIS PLAN.
 PLAN REPRODUCTION AND LICENSING NOTICE
 The printing or reproduction of any kind for marketing, construction or any use of this South Florida Design, Inc. The license number listed below grants the customer the right to construct one home from these plans at the specified legal description or address as stated in the license agreement. Any use of this plan or design without a valid license number will result in legal action as set forth by US Copyright Law.
 LICENSE # **SFD-00908-1G1-4346**

G1-4346-S
BRETT AND AMANDA BRANCH
SINGLE FAMILY HOME
3000 W. HIGHWAY 130
NEWCASTLE, OKLAHOMA 73065

Revisions		
No.	Date	Date
1	4	
2	5	
3	6	

Drawn By: D.A.
 Plan No: G1-4346-S
 Date: 07-28-2025
 Reviewed: 03-06-23 KP

CONFIDENTIAL COPYRIGHT SOUTH FLORIDA DESIGN, INC. PURSUANT TO SECTION 102 OF THE COPYRIGHT ACT, 17 U.S.C. ALL CONCEPTS, IDEAS, DESIGNS, ARRANGEMENTS, DRAWINGS, AND PLANS INDICATED OR REPRESENTED BY THIS DOCUMENT ARE COPYRIGHTED BY SOUTH FLORIDA DESIGN, INC. AS SUCH ALL CONCEPTS, IDEAS, DESIGNS, ARRANGEMENTS, DRAWINGS, AND PLANS INDICATED OR REPRESENTED BY THIS DOCUMENT ARE OWNED BY AND THE PROPERTY OF SOUTH FLORIDA DESIGN, INC. AND WERE CREATED, EVOLVED AND DEVELOPED FOR ITS OWN USE AND ARE NOT TO BE REPRODUCED, COPIED, REPRODUCED, OR TRANSMITTED IN ANY FORM OR BY ANY MEANS, ELECTRONIC OR MECHANICAL, INCLUDING PHOTOCOPYING, RECORDING, OR BY ANY INFORMATION STORAGE AND RETRIEVAL SYSTEM, WITHOUT THE WRITTEN PERMISSION OF SOUTH FLORIDA DESIGN, INC. PURSUANT TO SECTION 102 OF THE COPYRIGHT ACT, 17 U.S.C. PROTECTION FOR ARCHITECTURAL, ENGINEERING, OR CONSTRUCTION DRAWINGS MADE FOR HIRE OR AFTER DECEMBER 1, 1990, LASTS FOR 95 YEARS FROM THE DATE OF CREATION OF THE UNPUBLISHED PLANS, DRAWINGS, OR OTHER DOCUMENTS. ANY REPRODUCTION OR TRANSMISSION OF THESE DOCUMENTS WITHOUT THE WRITTEN PERMISSION OF SOUTH FLORIDA DESIGN, INC. IS A VIOLATION OF THE COPYRIGHT ACT, 17 U.S.C. 102. ANY REPRODUCTION OR TRANSMISSION OF THESE DOCUMENTS WITHOUT THE WRITTEN PERMISSION OF SOUTH FLORIDA DESIGN, INC. SHALL BE CONSIDERED A VIOLATION OF THE COPYRIGHT ACT, 17 U.S.C. 102. ANY REPRODUCTION OR TRANSMISSION OF THESE DOCUMENTS WITHOUT THE WRITTEN PERMISSION OF SOUTH FLORIDA DESIGN, INC. SHALL BE CONSIDERED A VIOLATION OF THE COPYRIGHT ACT, 17 U.S.C. 102. ANY REPRODUCTION OR TRANSMISSION OF THESE DOCUMENTS WITHOUT THE WRITTEN PERMISSION OF SOUTH FLORIDA DESIGN, INC. SHALL BE CONSIDERED A VIOLATION OF THE COPYRIGHT ACT, 17 U.S.C. 102.

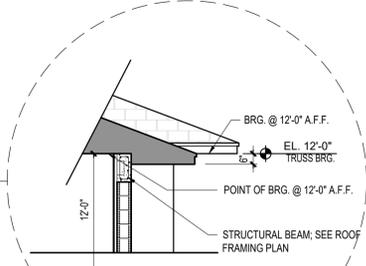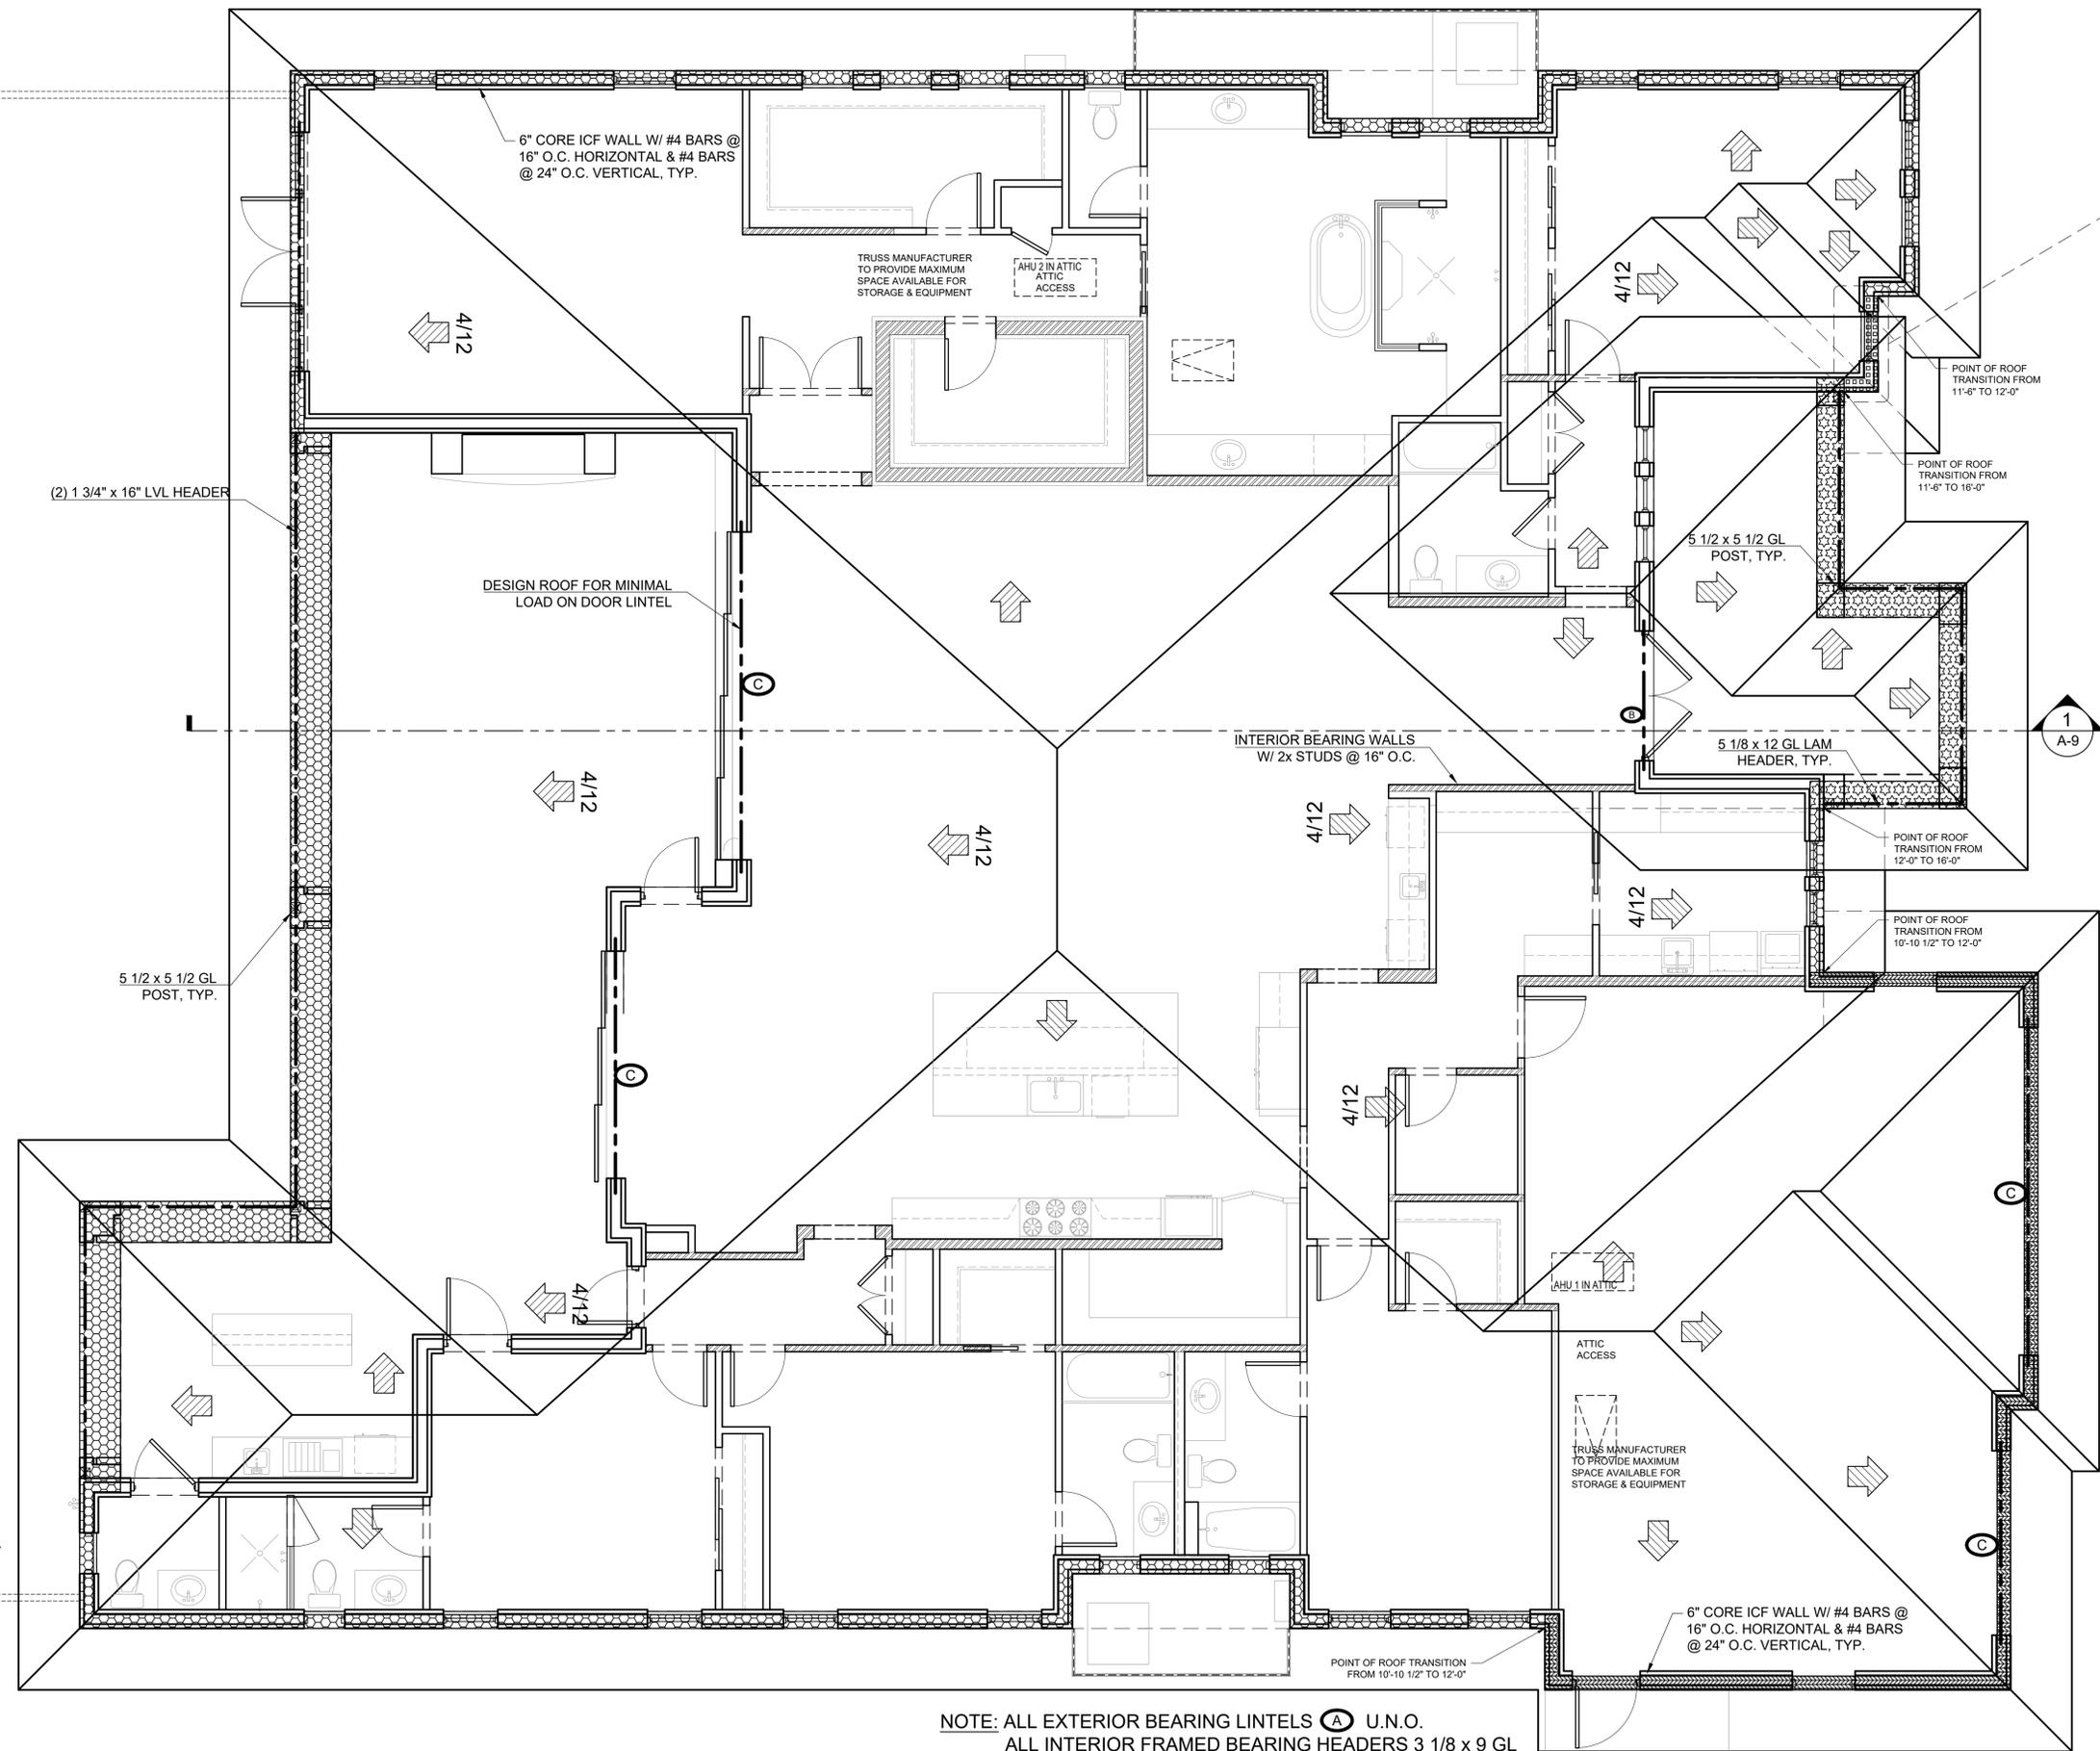

LINTEL SCHEDULE					
MARK	WIDTH	HEIGHT	BOTTOM REINF.	STIRRUPS	MAX SPAN
⊙	6	24	(1) #4 BAR	YES	5'-2"
⊙	6	24	(1) #5 BAR	YES	12'-0"
⊙	6	24	(2) #5 BAR	YES	16'-4"

REFER TO TABLE 5.1 ON PAGE A-07 FROM:
 "PRESCRIPTIVE METHOD FOR INSULATING CONCRETE FORMS IN RESIDENTIAL CONSTRUCTION Second Edition"
 BY HUD

NOTE: REFER TO TRUSS MANUFACTURES LAYOUT FOR TRUSS PLACEMENT

NOTE: ALL STRUCTURAL ASPECTS OF THIS PLAN ARE DESIGNED FOR A SPECIFIC SITE FOR WHICH THIS ORIGINAL PLAN WAS CONSTRUCTED. THEREFORE IT IS NECESSARY FOR THE BUYER OF THIS PLAN TO HIRE AN ARCHITECT OR STRUCTURAL ENGINEER LICENSED IN THE STATE WHICH THE PLAN IS TO BE CONSTRUCTED TO PROVIDE STRUCTURAL DESIGN DRAWINGS AND ADDRESS AND SPECIFY ALL STRUCTURAL ASPECTS AND COMPONENTS, INCLUDING BUT NOT LIMITED TO, COLUMNS, FOUNDATIONS, CONNECTIONS, AND WALL THICKNESS, REQUIRED FOR PERMIT AND CONSTRUCTION OF THESE PLANS. THE CERTIFIED STRUCTURAL DRAWINGS ARE TO ACCOMPANY THIS PLAN DURING CONSTRUCTION AND OTHER USES.

BEARING HEIGHTS LEGEND

- 10'-10 1/2" FROM 1ST. LIV. FIN. FL.
- 12'-0" FROM 1ST. LIV. FIN. FL. REFER TO OVERHANG DETAIL.
- 12'-0" FROM 1ST. LIV. FIN. FL.
- 16'-0" FROM 1ST. LIV. FIN. FL.

ROOF NOTES

- PRE-ENGINEERED WOOD ROOF TRUSSES @ 24" O.C.
- TYPICAL 4.5:12 PITCH UNLESS NOTED OTHERWISE. (SEE MFG. TRUSS PLANS).
- 3'-0" ROOF OVERHANGS UNLESS NOTED OTHERWISE.
- TRUSS MANUFACTURER TO SUBMIT ENGINEERED TRUSS DRAWINGS FOR APPROVAL.
- COORDINATION OF CONSTRUCTION INCLUDING VERIFICATION OF DIMENSIONS AND FIELD CONDITIONS, IS THE RESPONSIBILITY OF THE CONTRACTOR. ANY DISCREPANCIES SHALL BE BROUGHT TO THE ATTENTION OF THE DESIGN FIRM PRIOR TO CONSTRUCTION.
- PROVIDE ATTIC VENTILATION AS REQUIRED BY LOCAL RESIDENTIAL BUILDING CODE.
- ROOF PLAN FOR DESIGN PURPOSES ONLY. TRUSS MANUFACTURER TO SUBMIT ENGINEERED TRUSS DRAWINGS FOR APPROVAL.


NOTE: ALL EXTERIOR BEARING LINTELS (A) U.N.O. ALL INTERIOR FRAMED BEARING HEADERS 3 1/8 x 9 GL

ROOF FRAMING PLAN


SCALE: 1/4" = 1'-0"

All construction shall be in accordance with the 2018 I.R.C. and applicable local jurisdiction amendments.
 Written dimensions on these drawings have precedence over scale dimensions. Contractors shall verify and be responsible for all dimensions and conditions of the job. SFD shall be notified in writing of any variations or discrepancies from the dimensions, conditions and specifications shown by these drawings.


NOTE:
 ALL STRUCTURAL INFORMATION PROVIDED IN STRUCTURAL DRAWINGS BY ENGINEER OR ARCHITECT TAKE PRECEDENCE OVER ANY STRUCTURAL INFORMATION PROVIDED IN THIS PLAN.
 PLAN REPRODUCTION AND LICENSING NOTICE
 The printing or reproduction of any kind for marketing, construction or any use of this drawing without the written permission of South Florida Design, Inc. is prohibited. The license number listed below grants the customer the right to construct one home from these plans at the specified legal description or address as stated in the license agreement. Any use of this plan or design without a valid license number will result in legal action as set forth by US Copyright law.
 LICENSE # **SFD-00908-1G1-4346**

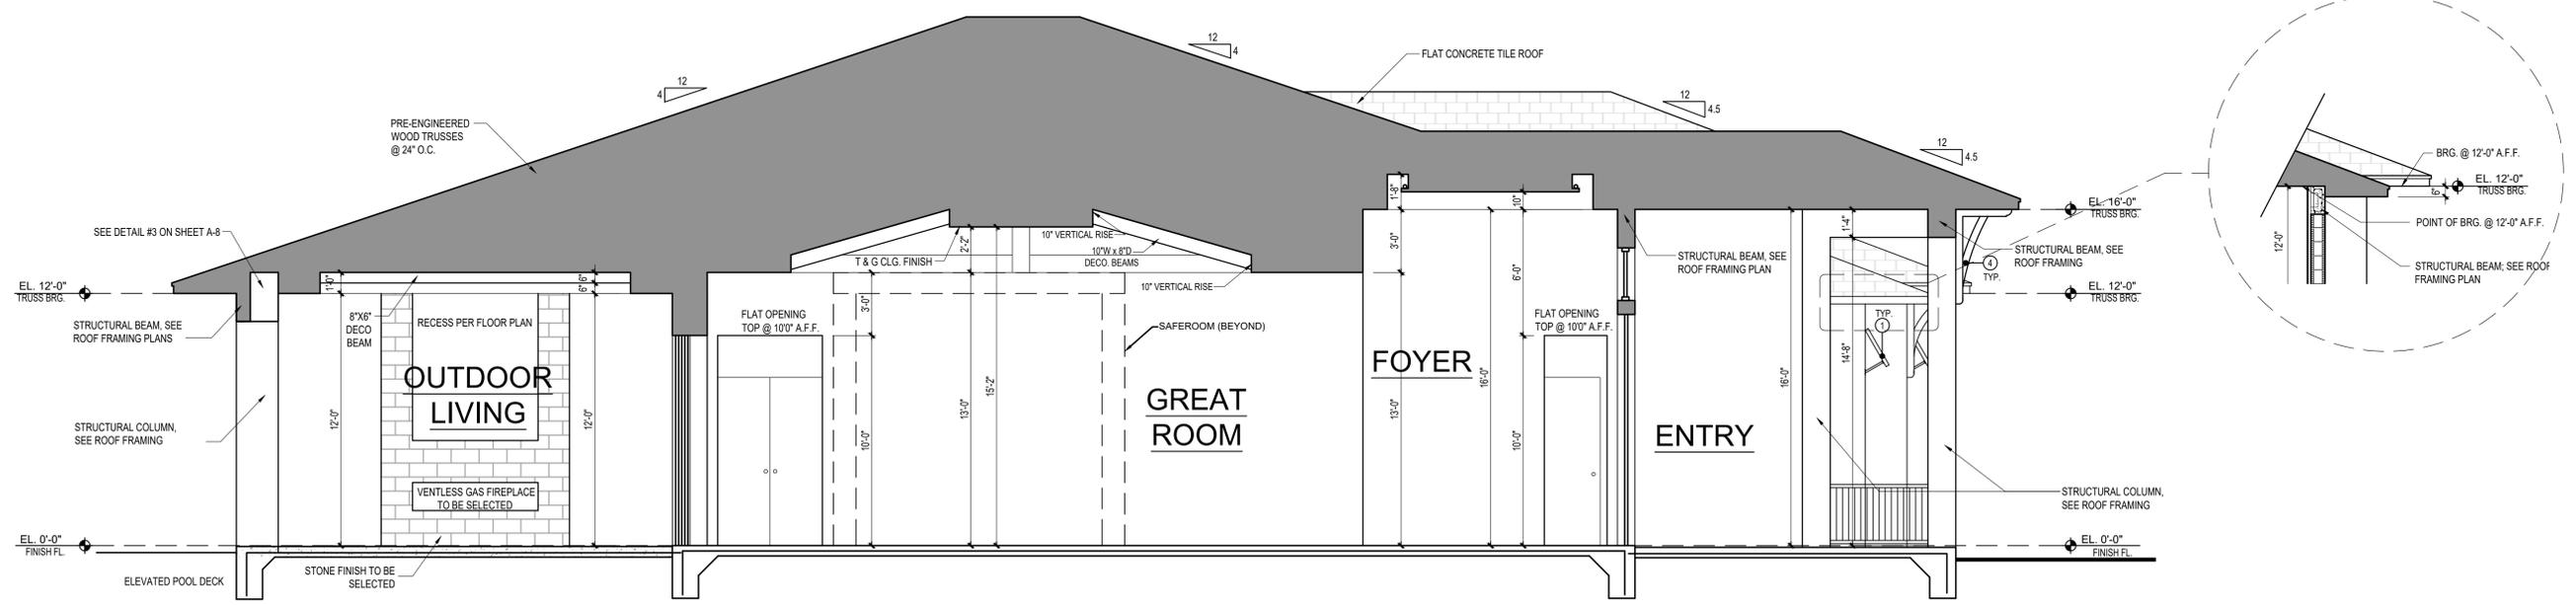

1 BUILDING SECTION
 SCALE: 1/4" = 1'-0"

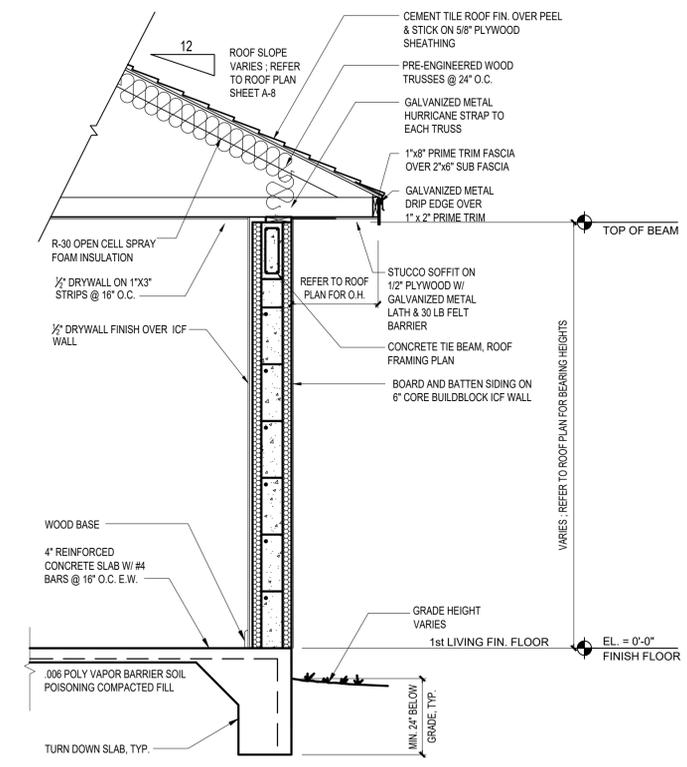

2 TYP. 1 STORY WALL SECTION
 SCALE: 1/2" = 1'-0"

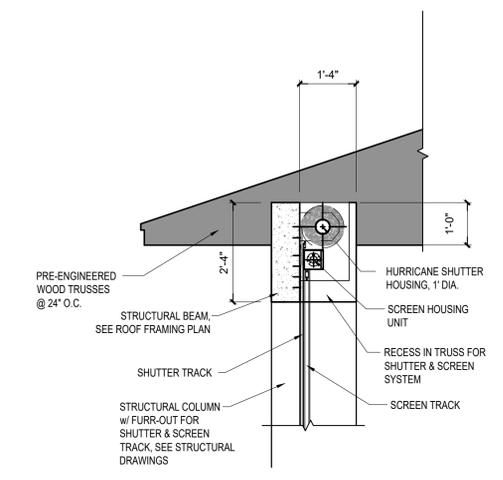

3 TYP. ROLL DOWN SHUTTER & SCREEN DETAIL @ COVERED LANAI
 SCALE: 1/2" = 1'-0"

G1-4346-S
BRETT AND AMANDA BRANCH
SINGLE FAMILY HOME
3000 W. HIGHWAY 130
NEWCASTLE, OKLAHOMA 73065

Revisions		
No.	Date	Date
1		4
2		5
3		6

Drawn By: D.A.
 Plan No: G1-4346-S
 Date: 07-28-2025
 Reviewed: 03-06-23 KP

CONFIDENTIAL COPYRIGHT SOUTH FLORIDA DESIGN, INC. PURSUANT TO SECTION 102 OF THE COPYRIGHT ACT, 17 U.S.C. ALL CONCEPTS, IDEAS, DESIGNS, ARRANGEMENTS, DRAWINGS, AND PLANS INDICATED OR REPRESENTED BY THIS DOCUMENT ARE COPYRIGHTED BY SOUTH FLORIDA DESIGN, INC. AS SUCH ALL CONCEPTS, IDEAS, DESIGNS, ARRANGEMENTS, DRAWINGS, AND PLANS INDICATED OR REPRESENTED BY THIS DOCUMENT ARE OWNED BY AND THE PROPERTY OF SOUTH FLORIDA DESIGN, INC. AND WERE CREATED, EVOLVED AND DEVELOPED FOR ITS OWN USE. NONE OF THE IDEAS, DESIGNS, ARRANGEMENTS, DRAWINGS, OR PLANS SHALL BE USED BY OR DISCLOSED TO ANY PERSON, ARCHITECTURAL OR ENGINEERING FIRM, CONSTRUCTION FIRM, SUBCONTRACTOR, FIRM, SUPPLIER, OR CORPORATION FOR ANY PURPOSE WHATSOEVER WITHOUT THE WRITTEN PERMISSION OF SOUTH FLORIDA DESIGN, INC. PURSUANT TO SECTION 102 OF THE COPYRIGHT ACT, 17 U.S.C. PROTECTION FOR ARCHITECTURAL WORK CREATED AS A HOME MADE FOR SALE OR AFTER DECEMBER 1, 1990, LASTS FOR 10 YEARS FROM THE DATE OF CREATION OF THE UNPUBLISHED PLANS. PROHIBITION FOR SALE, REPRODUCTION, REPRODUCTION OF A CRIMINAL OFFENSE UNDER SECTION 102 OF THE COPYRIGHT ACT, 17 U.S.C. 101, 102, 103, 199, 200. WRITTEN DIMENSIONS ON THESE DOCUMENTS SHALL HAVE PRECEDENCE OVER SCALE DIMENSIONS. CONTRACTORS SHALL VERIFY AND BE RESPONSIBLE FOR ALL DIMENSIONS AND CONDITIONS ON THE JOB AND THIS OFFICE MUST BE NOTIFIED OF ANY VARIATION FROM THE DIMENSIONS AND CONDITIONS SHOWN BY THESE DRAWINGS. SHOP DRAWINGS AND OR DETAILS MUST BE SUBMITTED TO THIS OFFICE FOR REVIEW BEFORE PROCEEDING WITH FABRICATION.

All construction shall be in accordance with the 2018 I.R.C. and applicable local jurisdiction amendments.
 Written dimensions on these drawings have precedence over scale dimensions. Contractors shall verify and be responsible for all dimensions and conditions of the job. SFD shall be notified in writing of any variations or discrepancies from the dimensions, conditions and specifications shown by these drawings.

NOTE:
 ALL STRUCTURAL INFORMATION PROVIDED IN STRUCTURAL DRAWINGS BY ENGINEER OR ARCHITECT TAKE PRECEDENCE OVER ANY STRUCTURAL INFORMATION PROVIDED IN THIS PLAN.
 PLAN REPRODUCTION AND LICENSING NOTICE
 The printing or reproduction of any kind for marketing, construction or any use of this plan without the express written permission of South Florida Design, Inc. is prohibited. The license number listed below grants the customer the right to construct one home from these plans at the specified legal description or address as stated in the license agreement. Any use of this plan or design without a valid license number will result in legal action as set forth by US Copyright law.
 LICENSE # **SFD-00908-1G1-4346**

FIRST FLOOR DOOR SCHEDULE

NO.	STYLE	SIZE		PROTECTION		MATERIAL	MANUFACTURER	REMARKS
		WIDTH	HEIGHT	SHUTTER	IMPACT			
101	OVERHEAD DOOR	9'-0"	9'-0"		YES	METAL	CLOPAY	
102	OVERHEAD DOOR	16'-0"	9'-0"		YES	METAL	CLOPAY	
103	SWING-DBL-EXT	PR 3'-0"	11'-0"		YES	STEEL	SUNGCOST IRON DOORS	
104	SWING-EXT	2'-8"	8'-0"		YES	FIBERGLASS		FIXED PANEL, FRENCH DOOR
105	SWING-DBL-EXT	PR 2'-8"	8'-0"		YES	STEEL	SUNGCOST IRON DOORS	
106	SWING-EXT	2'-8"	8'-0"		YES	FIBERGLASS		FIXED PANEL, FRENCH DOOR
107	SLIDER 4 PANEL	16'-0"	10'-0"		YES	ALUM		
108	SWING-EXT	2'-8"	8'-0"		YES	FIBERGLASS		
109	SWING-EXT	2'-8"	8'-0"		YES	FIBERGLASS		
110	SWING-EXT	3'-0"	8'-0"		YES	FIBERGLASS		
111	EXTERIOR FRENCH	3'-0"	8'-0"		YES	FIBERGLASS		
112	SWING-EXT	3'-0"	8'-0"		YES	FIBERGLASS		
113	SWING GARAGE	3'-0"	8'-0"			METAL		FIRE RATED W/ SELF CLOSING DEVICE
114	SWING	2'-6"	8'-0"			WOOD		
115	SWING	2'-8"	8'-0"			WOOD		
116	SWING	2'-8"	8'-0"			WOOD		
117	SWING	2'-6"	8'-0"			WOOD		
118	SWING-DBL	PR 1'-11"	8'-0"			WOOD		
119	SWING	2'-8"	8'-0"			WOOD		
120	POCKET	2'-8"	8'-0"			WOOD		
121	SWING	2'-8"	8'-0"			WOOD		
122	SHOWER SWING	2'-6"	7'-0"			GLASS		TEMP. GLASS
123	SWING	2'-8"	8'-0"			WOOD		
124	BYPASS-DBL	PR 3'-0"	8'-0"			WOOD		
125	SWING	2'-6"	8'-0"			WOOD		
126	SHOWER SWING	2'-6"	7'-0"			GLASS		TEMP. GLASS
127	POCKET	3'-0"	8'-0"			WOOD		
128	SWING	2'-6"	8'-0"			WOOD		
129	SHOWER SWING	2'-6"	8'-0"			GLASS		TEMP. GLASS
130	SWING-DBL	PR 2'-0"	8'-0"			WOOD		
131	SWING	2'-8"	8'-0"			WOOD		
132	BYPASS-DBL	PR 2'-6"	8'-0"			WOOD		
133	BYPASS-DBL	PR 2'-0"	8'-0"			WOOD		
134	SWING-DBL	PR 2'-6"	8'-0"			WOOD		
135	SWING	2'-8"	8'-0"			WOOD		
136	SWING	2'-6"	8'-0"			WOOD		
137	SWING	2'-0"	8'-0"			WOOD		
138	POCKET	3'-0"	8'-0"			WOOD		
139	SWING	2'-6"	8'-0"			WOOD		
140	SLIDER 3 PANEL	11'-0"	10'-0"			ALUM		

FIRST FLOOR WINDOW SCHEDULE

NO.	STYLE	SIZE		PROTECTION		MATERIAL	MANUFACTURER	REMARKS
		WIDTH	HEIGHT	SHUTTER	IMPACT			
101	FIXED GLASS	3'-1"	5'-3"		YES	WOOD	ANDERSEN	TOP @ 6'4" A.F.F.
102	CASEMENT	1'-9"	5'-5 1/2"		YES	WOOD	ANDERSEN	TOP @ 8'-0" A.F.F.
103	FIXED GLASS	1'-9"	2'-0"		YES	WOOD	ANDERSEN	TRANSOM
104	CASEMENT	1'-9"	5'-5 1/2"		YES	WOOD	ANDERSEN	TOP @ 8'-0" A.F.F.
105	FIXED GLASS	1'-9"	2'-0"		YES	WOOD	ANDERSEN	TRANSOM
106	FIXED GLASS	3'-0"	2'-6"		YES	WOOD	ANDERSEN	TRANSOM ABOVE ENTRY DOOR
107	FIXED GLASS	3'-0"	2'-6"		YES	WOOD	ANDERSEN	TRANSOM ABOVE ENTRY DOOR
108	CASEMENT	1'-9"	5'-5 1/2"		YES	WOOD	ANDERSEN	TOP @ 8'-0" A.F.F.
109	FIXED GLASS	1'-9"	2'-6"		YES	WOOD	ANDERSEN	TRANSOM
110	CASEMENT	1'-9"	5'-5 1/2"		YES	WOOD	ANDERSEN	TOP @ 8'-0" A.F.F.
111	FIXED GLASS	1'-9"	2'-6"		YES	WOOD	ANDERSEN	TRANSOM
112	CASEMENT	1'-9"	5'-5 1/2"		YES	WOOD	ANDERSEN	TOP @ 8'-0" A.F.F.
113	FIXED GLASS	1'-9"	2'-6"		YES	WOOD	ANDERSEN	TRANSOM
114	CASEMENT	2'-5"	5'-5 1/2"		YES	WOOD	ANDERSEN	TOP @ 8' A.F.F.
115	FIXED GLASS	2'-5"	2'-0"		YES	WOOD	ANDERSEN	TRANSOM
116	CASEMENT	2'-5"	5'-5 1/2"		YES	WOOD	ANDERSEN	TOP @ 8' A.F.F.
117	FIXED GLASS	2'-5"	2'-0"		YES	WOOD	ANDERSEN	TRANSOM
118	CASEMENT	2'-5"	5'-5 1/2"		YES	WOOD	ANDERSEN	TOP @ 8' A.F.F.
119	FIXED GLASS	2'-5"	2'-0"		YES	WOOD	ANDERSEN	TRANSOM
120	CASEMENT	3'-0 1/2"	5'-5 1/2"		YES	WOOD	ANDERSEN	TOP @ 8' A.F.F.
121	FIXED GLASS	3'-0 1/2"	2'-0"		YES	WOOD	ANDERSEN	TRANSOM
122	CASEMENT	3'-0 1/2"	5'-5 1/2"		YES	WOOD	ANDERSEN	TOP @ 8' A.F.F. ; EGRESS
123	FIXED GLASS	3'-0 1/2"	2'-0"		YES	WOOD	ANDERSEN	TRANSOM
124	FIXED GLASS	2'-6"	4'-0"		YES	WOOD	ANDERSEN	TOP @ 10'-0" A.F.F.
125	FIXED GLASS	2'-6"	4'-0"		YES	WOOD	ANDERSEN	TOP @ 10'-0" A.F.F.
126	FIXED GLASS	2'-0"	4'-0"		YES	WOOD	ANDERSEN	TOP @ 10' A.F.F.
127	FIXED GLASS	2'-6"	2'-0"		YES	WOOD	ANDERSEN	TOP @ 10' A.F.F.
128	FIXED GLASS	2'-6"	2'-0"		YES	WOOD	ANDERSEN	TOP @ 10' A.F.F.
129	FIXED GLASS	2'-6"	2'-0"		YES	WOOD	ANDERSEN	TOP @ 10' A.F.F.
130	CASEMENT	3'-0 1/2"	5'-5 1/2"		YES	WOOD	ANDERSEN	TOP @ 8' A.F.F.
131	FIXED GLASS	3'-0 1/2"	2'-0"		YES	WOOD	ANDERSEN	TRANSOM
132	CASEMENT	3'-0 1/2"	5'-5 1/2"		YES	WOOD	ANDERSEN	TOP @ 8' A.F.F.
133	FIXED GLASS	3'-0 1/2"	2'-0"		YES	WOOD	ANDERSEN	TRANSOM
134	FIXED GLASS	2'-8"	1'-4"		YES	WOOD	ANDERSEN	TRANSOM
135	FIXED GLASS	2'-8"	1'-4"		YES	WOOD	ANDERSEN	TRANSOM
136	FIXED GLASS	2'-8"	1'-4"		YES	WOOD	ANDERSEN	TRANSOM
137	FIXED GLASS	2'-8"	1'-4"		YES	WOOD	ANDERSEN	TRANSOM
138	FIXED GLASS	2'-8"	1'-4"		YES	WOOD	ANDERSEN	TRANSOM
139	CASEMENT	3'-0 1/2"	6'-0 1/2"		YES	WOOD	ANDERSEN	TOP @ 8' A.F.F. ;
140	FIXED GLASS	3'-0 1/2"	2'-0"		YES	WOOD	ANDERSEN	TRANSOM
141	FIXED GLASS	5'-0"	6'-0 1/2"		YES	WOOD	ANDERSEN	TOP @ 8' A.F.F. ;
142	FIXED GLASS	5'-0"	2'-0"		YES	WOOD	ANDERSEN	TRANSOM
143	CASEMENT	3'-0 1/2"	6'-0 1/2"		YES	WOOD	ANDERSEN	TOP @ 8' A.F.F. ;
144	FIXED GLASS	3'-0 1/2"	2'-0"		YES	WOOD	ANDERSEN	TRANSOM
145	FIXED GLASS	2'-8"	1'-4"		YES	WOOD	ANDERSEN	TRANSOM
146	FIXED GLASS	3'-0"	1'-4"		YES	WOOD	ANDERSEN	TRANSOM
147	FIXED GLASS	3'-0"	1'-4"		YES	WOOD	ANDERSEN	TRANSOM ABOVE DOOR
148	FIXED GLASS	2'-0"	4'-0"		YES	WOOD	ANDERSEN	TOP @ 10' A.F.F.
149	FIXED GLASS	2'-0"	4'-0"		YES	WOOD	ANDERSEN	TOP @ 10' A.F.F.
150	CASEMENT	2'-8"	5'-5 1/2"		YES	WOOD	ANDERSEN	TOP @ 8' A.F.F.
151	FIXED GLASS	2'-8"	2'-0"		YES	WOOD	ANDERSEN	TRANSOM
152	CASEMENT	2'-8"	5'-5 1/2"		YES	WOOD	ANDERSEN	TOP @ 8' A.F.F. ; EGRESS
153	FIXED GLASS	2'-8"	2'-0"		YES	WOOD	ANDERSEN	TRANSOM
154	CASEMENT	2'-8"	5'-3"		YES	WOOD	ANDERSEN	TOP @ 8' A.F.F. ; EGRESS
155	FIXED GLASS	2'-8"	2'-0"		YES	WOOD	ANDERSEN	TRANSOM
156	CASEMENT	2'-8"	5'-3"		YES	WOOD	ANDERSEN	TOP @ 8' A.F.F.
157	FIXED GLASS	2'-8"	2'-0"		YES	WOOD	ANDERSEN	TRANSOM
158	FIXED GLASS	2'-0"	4'-0"		YES	WOOD	ANDERSEN	TOP @ 10' A.F.F.
159	FIXED GLASS	2'-0"	4'-0"		YES	WOOD	ANDERSEN	TOP @ 10' A.F.F.
160	CASEMENT	3'-0 1/2"	5'-5 1/2"		YES	WOOD	ANDERSEN	TOP @ 8' A.F.F. ; EGRESS
161	FIXED GLASS	3'-0 1/2"	2'-0"		YES	WOOD	ANDERSEN	TRANSOM
162	CASEMENT	3'-0 1/2"	5'-5 1/2"		YES	WOOD	ANDERSEN	TOP @ 8' A.F.F. ; EGRESS
163	FIXED GLASS	3'-0 1/2"	2'-0"		YES	WOOD	ANDERSEN	TRANSOM
164	FIXED GLASS	3'-1"	5'-3"		YES	WOOD	ANDERSEN	TOP @ 6'4" A.F.F.

G1-4346-S
BRETT AND AMANDA BRANCH
SINGLE FAMILY HOME
3000 W. HIGHWAY 130
NEWCASTLE, OKLAHOMA 73065


Revisions			
No.	Date	No.	Date
1		4	
2		5	
3		6	

Drawn By: D.A.
 Plan No: G1-4346-S
 Date: 07-28-2025
 Reviewed: 03-06-23 KP


CONFIDENTIAL COPYRIGHT SOUTH FLORIDA DESIGN, INC. PURSUANT TO SECTION 102 OF THE COPYRIGHT ACT, 17 U.S.C. ALL CONCEPTS, IDEAS, DESIGNS, ARRANGEMENTS, DRAWINGS, AND PLANS INDICATED OR REPRESENTED BY THIS DOCUMENT ARE COPYRIGHTED BY SOUTH FLORIDA DESIGN, INC. AS SUCH ALL CONCEPTS, IDEAS, DESIGNS, ARRANGEMENTS, DRAWINGS, AND PLANS INDICATED OR REPRESENTED BY THIS DOCUMENT ARE OWNED BY AND ARE PROPERTY OF SOUTH FLORIDA DESIGN, INC. AND WERE CREATED, EVOLVED AND DEVELOPED FOR ITS OWN USE NONE OF THE IDEAS, DESIGNS, ARRANGEMENTS, DRAWINGS, OR PLANS INDICATED OR REPRESENTED BY THIS DOCUMENT SHALL BE USED BY OR DISCLOSED TO ANY PERSON, ARCHITECTURAL OR ENGINEERING FIRM, CONSTRUCTION FIRM, SUBCONTRACTOR, FIRM, SUPPLIER, OR CORPORATION FOR ANY PURPOSE WHATSOEVER WITHOUT THE WRITTEN PERMISSION OF SOUTH FLORIDA DESIGN, INC. PURSUANT TO SECTION 102 OF THE COPYRIGHT ACT, 17 U.S.C. PROTECTION FOR AN ARCHITECTURAL WORK CREATED AS A HOME MADE FOR HIRE OR AFTER DECEMBER 1, 1991, LASTS FOR 95 YEARS FROM THE DATE OF CREATION OF THE WORK OR 120 YEARS FROM THE DATE OF CREATION OF THE UNPUBLISHED PLANS, DRAWINGS, OR OTHER DOCUMENTS. REPRODUCTION OR OTHER CRIMINAL OFFENSE UNDER SECTION 102 OF THE COPYRIGHT ACT, 17 U.S.C. 101, 102, 103, 789,

All construction shall be in accordance with the 2018 I.R.C. and applicable local jurisdiction amendments.
 Written dimensions on these drawings have precedence over scale dimensions. Contractors shall verify and be responsible for all dimensions and conditions of the job. SFD shall be notified in writing of any variations or discrepancies from the dimensions, conditions and specifications shown by these drawings.


NOTE:
 ALL STRUCTURAL INFORMATION PROVIDED IN STRUCTURAL DRAWINGS BY ENGINEER OR ARCHITECT TAKE PRECEDENCE OVER ANY STRUCTURAL INFORMATION PROVIDED IN THIS PLAN.
 PLAN REPRODUCTION AND LICENSING NOTICE
 The printing or reproduction of any kind for marketing, construction or any use of this drawing without the written permission of South Florida Design, Inc. is prohibited. The license number listed below grants the customer the right to construct one home from these plans at the specified legal description or address as stated in the license agreement. Any use of this plan or design without a valid license number will result in legal action as set forth by US Copyright law.
 LICENSE # **SFD-00908-1G1-4346**

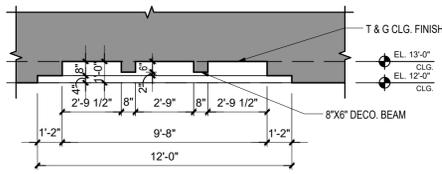


1 CEILING DETAIL AT STUDY
 SCALE: 1/4" = 1'-0"

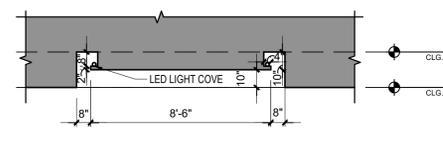


2 CEILING DETAIL AT FOYER
 SCALE: 1/4" = 1'-0"

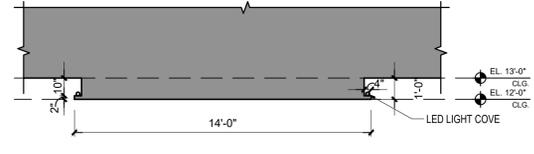


3 CEILING DETAIL AT KITCHEN
 SCALE: 1/4" = 1'-0"

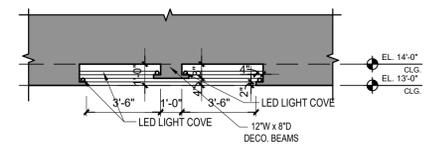


4 CEILING DETAIL AT DINING
 SCALE: 1/4" = 1'-0"

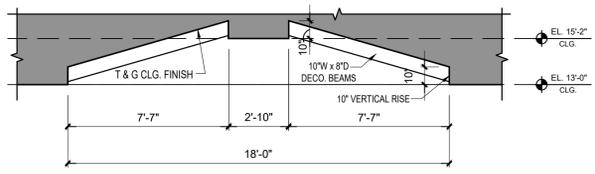


5 CEILING DETAIL AT GREAT ROOM
 SCALE: 1/4" = 1'-0"

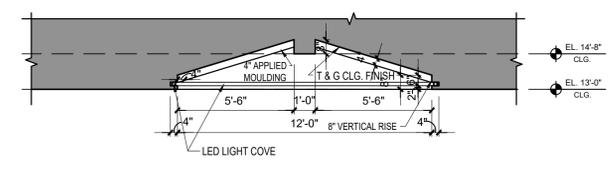


6 CEILING DETAIL AT MASTER SUITE
 SCALE: 1/4" = 1'-0"

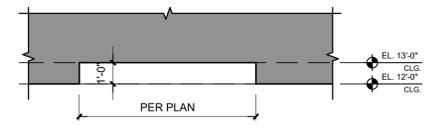

7 CEILING DETAIL AT BEDROOM #2, 3 AND 4
 SCALE: 1/4" = 1'-0"

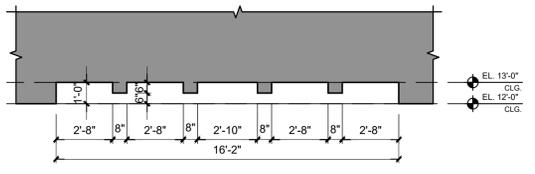

8 CEILING DETAIL AT COVERED LANAI
 SCALE: 1/4" = 1'-0"

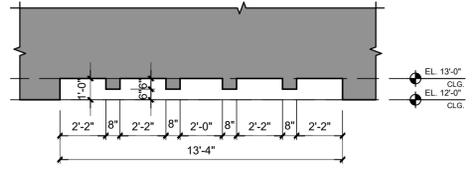

9 CEILING DETAIL AT COVERED LANAI
 SCALE: 1/4" = 1'-0"

G1-4346-S
BRETT AND AMANDA BRANCH
SINGLE FAMILY HOME
3000 W. HIGHWAY 130
NEWCASTLE, OKLAHOMA 73065

Revisions		
No.	Date	Description
1		4
2		5
3		6

Drawn By: D.A.
 Plan No: G1-4346-S
 Date: 07-28-2025
 Reviewed: 03-06-23 KP

CONFIDENTIAL COPYRIGHT SOUTH FLORIDA DESIGN, INC. PURSUANT TO SECTION 102 OF THE COPYRIGHT ACT, 17 U.S.C. ALL CONCEPTS, IDEAS, DESIGNS, ARRANGEMENTS, DRAWINGS, AND PLANS INDICATED OR REPRESENTED BY THIS DOCUMENT ARE COPYRIGHTED BY SOUTH FLORIDA DESIGN, INC. AS SUCH ALL CONCEPTS, IDEAS, DESIGNS, ARRANGEMENTS, DRAWINGS, AND PLANS INDICATED OR REPRESENTED BY THIS DOCUMENT ARE OWNED BY AND THE PROPERTY OF SOUTH FLORIDA DESIGN, INC. AND WERE CREATED, EVOLVED AND DEVELOPED FOR ITS OWN USE. NONE OF THE SCAL, DESIGNS, ARRANGEMENTS, OR PLANS SHALL BE USED BY OR DISCLOSED TO ANY PERSON, ARCHITECTURAL OR ENGINEERING FIRM, CONSTRUCTION FIRM, SUBCONTRACTOR, FIRM, SUPPLIER, OR CORPORATION FOR ANY PURPOSE WHATSOEVER WITHOUT THE WRITTEN PERMISSION OF SOUTH FLORIDA DESIGN, INC. PURSUANT TO SECTION 102 OF THE COPYRIGHT ACT, 17 U.S.C. PROTECTION FOR ARCHITECTURAL, WORK CREATED AS A HOME MADE FOR HIRE OR AFTER DECEMBER 1, 1990, LASTS FOR 95 YEARS FROM THE DATE OF PUBLICATION OF THE WORK OR FOR 120 YEARS FROM THE DATE OF CREATION OF THE UNPUBLISHED PLANS, WHICHEVER TERM ELIGES. WARNING: REPRODUCTION OR USE OF A ORIGINAL OR FEDERAL SECTION 102 OF THE COPYRIGHT ACT, 17 U.S.C. 101, 102, 103, 999, 1000.

CEILING DETAILS

NOTE:
ALL STRUCTURAL ASPECTS OF THIS PLAN ARE DESIGNED FOR A SPECIFIC SITE FOR WHICH THIS ORIGINAL PLAN WAS CONSTRUCTED. THEREFORE IT IS NECESSARY FOR THE BUYER OF THIS PLAN TO HIRE AN ARCHITECT OR STRUCTURAL ENGINEER LICENSED IN THE STATE WHICH THE PLAN IS TO BE CONSTRUCTED TO PROVIDE STRUCTURAL DESIGN DRAWINGS AND ADDRESS AND SPECIFY ALL STRUCTURAL ASPECTS AND COMPONENTS, INCLUDING BUT NOT LIMITED TO, COLUMNS, FOUNDATIONS, CONNECTIONS, AND WALL THICKNESS, REQUIRED FOR PERMIT AND CONSTRUCTION OF THESE PLANS. THE CERTIFIED STRUCTURAL DRAWINGS ARE TO ACCOMPANY THIS PLAN DURING CONSTRUCTION AND OTHER USES.

NOTE:
ALL STAIR RISERS, TREADS, BEAM HEIGHTS, AND DIMENSIONS TO BE COORDINATED WITH ENGINEERED DRAWINGS. ANY DISCREPANCIES SHALL BE BROUGHT TO THE ATTENTION OF SOUTH FLORIDA DESIGN FOR REVIEW PRIOR TO CONSTRUCTION.

TREADS AND RISERS MAY VARY DUE TO FIELD CONDITIONS. BUYER TO VERIFY ALL EXTERIOR STAIR WITH SITE CONDITIONS BEFORE START OF CONSTRUCTION

FOUNDATION TO BE ENGINEERED

SFD
South Florida Design, Inc.
8899 Timberwilde Dr.
Suite 2
Bonita Springs, FL 34135
(239)-431-1818

All construction shall be in accordance with the 2018 I.R.C. and applicable local jurisdiction amendments. Written dimensions on these drawings have precedence over scale dimensions. Contractors shall verify and be responsible for all dimensions and conditions of the job. SFD shall be notified in writing of any variations or discrepancies from the dimensions, conditions and specifications shown by these drawings.

NOTE:
ALL STRUCTURAL INFORMATION PROVIDED IN STRUCTURAL DRAWINGS BY ENGINEER OR ARCHITECT TAKE PRECEDENCE OVER ANY STRUCTURAL INFORMATION PROVIDED IN THIS PLAN.
PLAN REPRODUCTION AND LICENSING NOTICE
The printing or reproduction of any kind for marketing, construction or any use of this drawing without the written permission of South Florida Design, Inc. is prohibited. The license number listed below grants the customer the right to construct one home from these plans at the specified legal description or address as stated in the license agreement. Any use of this plan or copyright law without a valid license number will result in legal action as set forth by US Copyright law.
LICENSE # SFD-00908-1G1-4346


G1-4346-S
BRETT AND AMANDA BRANCH
SINGLE FAMILY HOME
3000 W. HIGHWAY 130
NEWCASTLE, OKLAHOMA 73065

Revisions		
No.	Date	Date
1	4	
2	5	
3	6	

Drawn By: D.A.
Plan No: G1-4346-S
Date: 07-28-2025
Reviewed: 03-06-23 KP

CONFIDENTIAL COPYRIGHT SOUTH FLORIDA DESIGN, INC. PURSUANT TO SECTION 107 OF THE COPYRIGHT ACT, 17 U.S.C. ALL CONCEPTS, IDEAS, DESIGNS, ARRANGEMENTS, DRAWINGS, AND PLANS INDICATED OR REPRESENTED BY THIS DOCUMENT ARE COPYRIGHTED BY SOUTH FLORIDA DESIGN, INC. AS SUCH ALL CONCEPTS, IDEAS, DESIGNS, ARRANGEMENTS, DRAWINGS AND PLANS INDICATED OR REPRESENTED BY THIS DOCUMENT ARE OWNED BY AND THE PROPERTY OF SOUTH FLORIDA DESIGN, INC. AND WERE CREATED, EVOLVED AND DEVELOPED FOR ITS OWN USE AND ARE NOT TO BE REPRODUCED, COPIED, REPRODUCED, OR TRANSMITTED IN ANY FORM OR BY ANY MEANS, ELECTRONIC OR MECHANICAL, INCLUDING PHOTOCOPYING, RECORDING, OR BY ANY INFORMATION STORAGE AND RETRIEVAL SYSTEM, WITHOUT THE WRITTEN PERMISSION OF SOUTH FLORIDA DESIGN, INC. PURSUANT TO SECTION 107 OF THE COPYRIGHT ACT, 17 U.S.C. PROTECTION FOR ARCHITECTURAL DRAWINGS OR PLANS MADE FOR SALE OR AFTER DECEMBER 1, 1990, LASTS FOR 95 YEARS FROM THE DATE OF CREATION OF THE UNPUBLISHED PLANS, AND FOR 70 YEARS FROM THE DATE OF CREATION OF THE PUBLISHED PLANS. UNAUTHORIZED DISSEMINATION OF UNPUBLISHED PLANS OR PUBLISHED PLANS WITHOUT THE WRITTEN PERMISSION OF SOUTH FLORIDA DESIGN, INC. CONSTITUTE TRADE SECRET MISAPPROPRIATION IN VIOLATION OF 28 U.S.C. 1835, 1836, AND OTHER LAWS. THE CONCEPTS, IDEAS, DESIGNS, ARRANGEMENTS, DRAWINGS, AND PLANS DISCLOSED ARE COPYRIGHTED AND HEREBY BE PATENTED OR IN THE SUBJECT OF PENDING PATENT APPLICATION. ANYONE VIOLATING THE INTENT OF THIS COPYRIGHT PROTECTION SHALL BE PROSECUTED TO THE FULL EXTENT OF THE FEDERAL, STATE AND LOCAL LAWS. WRITTEN DIMENSIONS ON THESE DOCUMENTS SHALL HAVE PRECEDENCE OVER SCALE DIMENSIONS. CONTRACTORS SHALL VERIFY AND BE RESPONSIBLE FOR ALL DIMENSIONS AND CONDITIONS ON THE JOB AND THIS OFFICE MUST BE NOTIFIED OF ANY VARIATION FROM THE DIMENSIONS AND CONDITIONS SHOWN ON THESE DRAWINGS. SHOP DRAWINGS AND/OR DETAILS MUST BE SUBMITTED TO THIS OFFICE FOR REVIEW BEFORE PROCEEDING WITH FABRICATION.

SHEET
A-12
PERMIT SET

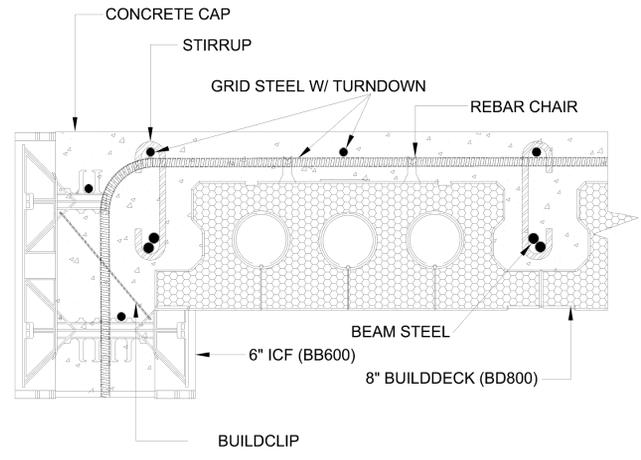

BUILDCLIP IS USED TO SUPPORT THE OUTER TOP SECTION OF A BUILDBLOCK ICF WHEN THE INNER PANEL HAS BEEN TRIMMED TO ALLOW CONNECTION TO A CONCRETE SLAB OR DECK APPLICATION. USE WITH BUILDDECK AS SHOWN.

NOTE:
BUILDCLIP IS NOT APPLICABLE FOR BUILDLOCK KNOCKDOWN FORMS, OR GLOBALBLOCK ALL FOAM ICF.



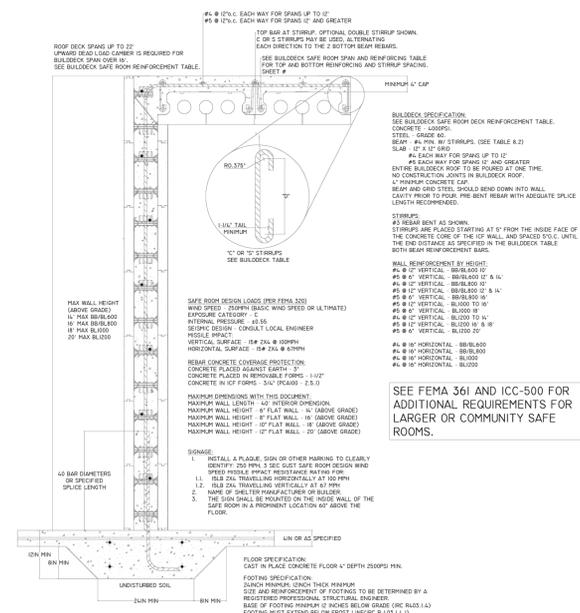


FIGURE 8.1 INTERIOR WALL (SLAB ON GRADE)

<p>NOTE: CONSTRUCTION SHALL BE IN ACCORDANCE WITH ALL APPLICABLE LOCAL & NATIONAL CODES. THIS DOCUMENT IS PROVIDED AS A BENEFIT. IT IS THE RESPONSIBILITY OF THE USER TO MODIFY THIS DOCUMENT ACCORDING TO APPLICABLE LOCAL AND NATIONAL CODES TO RESEARCH & UNDERSTAND SAFE METHODS OF USE & HANDLE OF PRODUCT. ALL DRAWINGS ARE SUBJECT TO CHANGE WITHOUT NOTICE. BUILDBLOCK ASSUMES NO LIABILITY FROM THE USE OF THIS DOCUMENT.</p>	8 INCH BUILDDECK WITH BUILDCLIP
	DATE / REVISION / BY: 7-1-23 / 1 / AJ
	SCALE: NTS
	FILE NAME: 1.701 - BD800

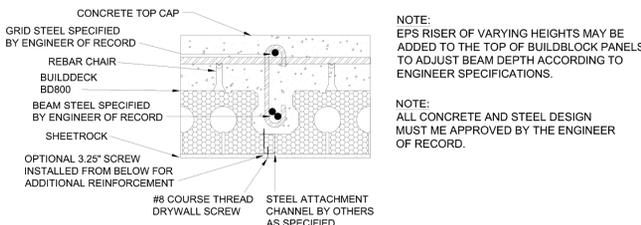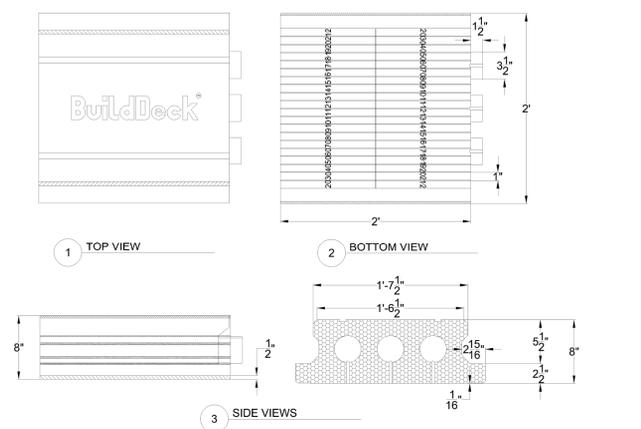

<p>NOTE: CONSTRUCTION SHALL BE IN ACCORDANCE WITH ALL APPLICABLE LOCAL & NATIONAL CODES. THIS DOCUMENT IS PROVIDED AS A BENEFIT. IT IS THE RESPONSIBILITY OF THE USER TO MODIFY THIS DOCUMENT ACCORDING TO APPLICABLE LOCAL AND NATIONAL CODES TO RESEARCH & UNDERSTAND SAFE METHODS OF USE & HANDLE OF PRODUCT. ALL DRAWINGS ARE SUBJECT TO CHANGE WITHOUT NOTICE. BUILDBLOCK ASSUMES NO LIABILITY FROM THE USE OF THIS DOCUMENT.</p>	8 INCH BUILDDECK BLOCK
	DATE / REVISION / BY: 7-1-23 / 1 / AJ
	SCALE: NTS
	FILE NAME: 1.700 - BD800

8.0 BUILDLOCK SAFE ROOM ENGINEERING

BUILDLOCK AND BUILDLOCK KNOCKDOWN FLAT WALL SAFE ROOM TABLES

TABLE 8.1 BUILDLOCK SAFE ROOM WALL REINFORCEMENT *

HEIGHT (ABOVE GRADE)	BLOCK CORE WIDTH							
	6"		8"		10"		12"	
	VERTICAL	HORIZONTAL	VERTICAL	HORIZONTAL	VERTICAL	HORIZONTAL	VERTICAL	HORIZONTAL
10	#4 @ 12"	#4 @ 16"	#4 @ 12"	#4 @ 16"	#4 @ 12"	#4 @ 16"	#4 @ 12"	#4 @ 16"
12	#5 @ 6"	#4 @ 16"	#5 @ 12"	#4 @ 16"	#4 @ 12"	#4 @ 16"	#4 @ 12"	#4 @ 16"
14	#5 @ 6"	#4 @ 16"	#5 @ 12"	#4 @ 16"	#4 @ 12"	#4 @ 16"	#4 @ 12"	#4 @ 16"
16			#5 @ 6"	#4 @ 16"	#5 @ 12"	#4 @ 16"	#5 @ 12"	#4 @ 16"
18					#5 @ 6"	#4 @ 16"	#5 @ 12"	#4 @ 16"
20							#5 @ 6"	#4 @ 16"

TABLE 8.2 TABLE BUILDDECK SAFE ROOM DECK REINFORCEMENT TABLE *

SPAN (FT)	BD800				BD1000				BD1200				UPWARD CAMBER
	REBAR		STIRRUP		REBAR		STIRRUP		REBAR		STIRRUP		
	BOTTOM	TOP	END DISTANCE	"D"	BOTTOM	TOP	END DISTANCE	"D"	BOTTOM	TOP	END DISTANCE	"D"	
12	2-#5	1-#5	48"	6-1/4"	2-#4	1-#5	48"	8-1/4"	2-#4	1-#5	48"	10-1/4"	N/A
14	2-#6	1-#5	60"	6-1/4"	2-#5	1-#5	48"	8-1/4"	2-#4	1-#5	48"	10-1/4"	N/A
16	2-#7	1-#6	72"	6-1/4"	2-#6	1-#6	60"	8-1/4"	2-#5	1-#5	48"	10-1/4"	3/4"
18					2-#7	1-#6	72"	8-1/4"	2-#5	1-#6	60"	10-1/4"	3/4"
20									2-#6	1-#6	72"	10-1/4"	1"
22									2-#7	1-#7	84"	10-1/4"	1-1/2"

* Refer to Figures 8.1 - 8.4 for further details.

